PLUMBING FIXTURE SCHEDULE - CLUBHOUSE								
MARK	DESCRIPTION	MANUFACTURER	SUPPLY FITTING	FAUCET	DRAINS	TRAP	REMARKS	
WC-1	WATER CLOSET FLOOR MTD (1)	AMERICAN STANDARD 3451.001	SLOAN "REGAL" 111-YB-YC-YK-ADA	-	PROVIDED BY PLUMBING CONTRACTOR		ADA	
UR-1	URINAL	AMERICAN STANDARD 6541.132	SLOAN "REGAL" 186-YB-YC-YK-ADA	-	PROVIDED BY PLUMBING CONTRACTOR	-	ADA	
L-1	LAVATORY WALL HUNG	AMERICAN STANDARD 0356.012	PROVIDED BY PLUMBING CONTRACTOR	MOEN L4621	PROVIDED BY PLUMBING CONTRACTOR	PROVIDED BY PLUMBING CONTRACTOR	ADA	
S-1	SINK - SINGLE	KOHLER K-3349-2	PROVIDED BY PLUMBING CONTRACTOR	KOHLER K-16112-4A-BN	PROVIDED BY PLUMBING CONTRACTOR	PROVIDED BY PLUMBING CONTRACTOR	PROVIDE WITH GARBAGE DISPOSAL	
EWC-1	ELECTRIC WATER COOLER	ELKAY LZSTL8WSSP	PROVIDED BY PLUMBING CONTRACTOR	-	PROVIDED BY PLUMBING CONTRACTOR	PROVIDED BY PLUMBING CONTRACTOR	PROVIDE WITH WATER FILTER, ADA AND BOTTLE FILLER	
JS-1	JANITOR SINK	FIAT MSB-2424	PROVIDED BY PLUMBING CONTRACTOR	FIAT 830-AA	PROVIDED BY PLUMBING CONTRACTOR	PROVIDED BY PLUMBING CONTRACTOR		
HB-1	HOSE BIBB	WOODFORD MODEL 24	-	-	-	-	PROVIDE WITH VACUUM BREAKER	
FD-1	FLOOR DRAIN	JOSAM 30000-S-50-T-17	PROVIDED BY PLUMBING CONTRACTOR	-	PROVIDED BY PLUMBING CONTRACTOR	PROVIDED BY PLUMBING CONTRACTOR		
UB-1	REFRIGERATOR BOX	WATER-TITE AB9701HACP	PROVIDED BY PLUMBING CONTRACTOR	-	-	-		

PLUMBING FIXTURE CONNECTION SCHEDULE - CLUBHOUSE							
ITEM	DESCRIPTION	WASTE	TRAP	VENT	CW	HW	REMARKS
WC-1	WATER CLOSET	3"	INTEG	2"	1"	-	FLR MTD FL VLV 1.6 GAL ADA
UR-1	URINAL	2"	2"	1-1/2"	3/4"	-	ADA
L-1	LAVATORY	2"	1-1/4"	1-1/2"	1/2"	1/2"	WL HG ADA
S-1	SINK - SINGLE	2"	1-1/2"	1-1/2"	1/2"	1/2"	
EWC-1	ELEC. WATER COOLER	2"	1-1/2"	1-1/2"	1/2"	-	ADA
JS-1	JANITOR'S SINK	3"	3"	1-1/2"	3/4"	3/4"	

TK

TANK

WL WALL

CTR	COUNTERTOP	MTD	MOUNTED
FLR	FLOOR	GAL	GALLONS
HG	HUNG	SS	STAINLESS STEEL
FL	FLUSH	ADA	AMERICAN DISABILITIES ACT
VLV	VALVE		COMPLIANT

1. (1) WITH ELONGATED OPEN FRONT SEAT LESS COVER.

ABBREVIATIONS

ELECTRIC WATER HEATER SCHEDULE - CLUBHOUSE					
MARK		EWH-1 & 2			
MANUFACTURER		A.O. SMITH			
MODEL		ENLB-40			
STORAGE CAPACITY	(GAL)	35			
RECOVERY	(GPH)	31 @ 80°R			
UNIT SIZE		32" x 24" DIA.			
OPERATIONAL WEIGHT	(LBS)	409			
KW INPUT		6.0			
EFFICIENCY		95			
VOLTAGE/PHASE/HZ		240/1/60			

HOT WATER RECIRC. PUMP SCHEDULE				
MARK	HWRP-1			
MANUFACTURER	ARMSTRONG			
MODEL	H-32			
VOLTAGE/H.P.	120/ 1/6			
PHASE	1			
RPM	1750			
CAPACITY (GPM)	10			
TOTAL HEAD (FEET)	10			

	PLUMBING EQUIPMENT SCHEDULE								
MARK	FIXTURE	MANUF./MODEL	REMARKS						
WCO-1	WALL CLEAN-OUT	CHARLOTTE PIPE NO. 105	CLEANOUT ADAPTER TO BE FITTED TO CLEANOUT TEE FITTING. SIZE AS INDICATED ON DRAWINGS. PROVIDE ZURN #Z-1468 BRONZE RAISED HEX HEAD PLUG AND ROUND STAINLESS STEEL WALL ACCESS COVER WITH SECURING SCREW.						
ECO-1	EXTERIOR CLEAN-OUT	-	PROVIDE CLEAN-OUT WITH 2-WAY CLEAN-OUT TEE. (LAWN. IN FLUSH 12"x12"x4" CONCRETE PAD)						
FCO-1	FLOOR CLEAN-OUT	JONESPEC #CO-2450	ADJUSTABLE FLOOR CLEANOUT WITH PVC BODY WITH ADJUSTABLE NICKLE BRONZE AND ABS TAPER THREAD PLUG. SIZE AS INDICATED ON DRAWINGS.						


		PLUI	MBING FIX	TURE S	CHEDUL	E	
MARK	DESCRIPTION	MANUFACTURER	SUPPLY FITTING	FAUCET	DRAINS	TRAP	REMARKS
WC-1	WATER CLOSET FLOOR MTD	GERBER SE-21-112 COMFORT TOILET SEAT C1011	PROVIDED BY PLUMBING CONTRACTOR	-	PROVIDED BY PLUMBING CONTRACTOR	-	
L-1	LAVATORY COUNTERTOP	PROFLOW PF20178BS 20"X17"	PLUMBING CONTRACTOR	PFISTER J142-800K	PLUMBING CONTRACTOR	PLUMBING CONTRACTOR	
S-1	SINK ONE COMPARTMENT	MAINCRAFT 33X18X9, 18 GA. STAINLESS STEEL	PROVIDED BY PLUMBING CONTRACTOR	PFISTER G529-PFSS	PROVIDED BY PLUMBING CONTRACTOR	PROVIDED BY PLUMBING CONTRACTOR	PROVIDE WITH 1/2 HP DISPOSAL
BT-1	BATHTUB	STERLING 71041112 60"X29"X17"	PROVIDED BY PLUMBING CONTRACTOR	PFISTER R89-030K	PROVIDED BY PLUMBING CONTRACTOR	PROVIDED BY PLUMBING CONTRACTOR	
SH-1	SHOWER	STERLING 72131100 34X60X4-1/2	-	PFISTER R89-020K	-	-	SIOUX CHIEF 832-36-P-NR-V
WB-1	WASHING MACHINE BOX	WATER-TITE W4701HACP	PROVIDED BY PLUMBING CONTRACTOR	-	PROVIDED BY PLUMBING CONTRACTOR	PROVIDED BY PLUMBING CONTRACTOR	
HB-1	HOSE BIBB	WOODFORD MODEL 24	-	-	-	-	PROVIDE WITH VACUUM BREAKER
DW-1	DISHWASHER	BY OTHERS	PROVIDED BY PLUMBING CONTRACTOR	-	PROVIDED BY PLUMBING CONTRACTOR	-	NOTE 1
UB-1	REFRIGERATOR BOX	WATER-TITE AB9701HACP	PROVIDED BY PLUMBING CONTRACTOR	-	-	-	
FD-1	FLOOR DRAIN	JOSAM 30000-S-50-T-17	PROVIDED BY PLUMBING CONTRACTOR	-	PROVIDED BY PLUMBING CONTRACTOR	PROVIDED BY PLUMBING CONTRACTOR	

	REMARKS	HW	CW	VENT	TRAP	WASTE	DESCRIPTION	ГЕМ
	FLR MTD TK 1.6 GAL	-	1/2"	2"	INTEG	3"	WATER CLOSET	VC-1
	CTR	1/2"	1/2"	1-1/2"	1-1/4"	2"	LAVATORY	L-1
	SS	1/2"	1/2"	1-1/2"	1-1/2"	2"	SINK - SINGLE	S-1
		1/2"	1/2"	1-1/2"	1-1/2"	2"	BATHTUB	BT-1
		1/2"	1/2"	1-1/2"	1-1/2"	2"	SHOWER	SH-1
		1/2"	1/2"	2"	2"	2"	WASHER BOX	WB-1
	NOTE 1	1/2"	-	-	-	5/8"	DISHWASHER	DW-1
ABBREVIATIONS								
	TK TANK			NTED	TD MOU	M.	COUNTERTOP	CTR
	WL WALL			LONS	AL GALI	G	FLOOR	FLR
	HC HANDICAPPED		SS STAINLESS STEEL			SS	HUNG	HG
		Γ	BILITIES ACT	RICAN DISA	DA AME	IA	FLUSH	FL
				PLIANT	COM		VALVE	VLV

WATER TIGHT


SLEEVE -

MARK		EWH-1	EWH-2
MANUFACTURER		A.O. SMITH	A.O. SMITH
MODEL		ENTB-50	ENLB-40
STORAGE CAPACITY	(GAL)	45	35
RECOVERY	(GPH)	31 @ 80°R	31 @ 80°R
UNIT SIZE		60" x 21" DIA.	32" x 24" DIA.
OPERATIONAL WEIGHT	(LBS)	505	409
KW INPUT		6.0	6.0
EFFICIENCY		95	95
VOLTAGE/PHASE/HZ		208/1/60	208/1/60

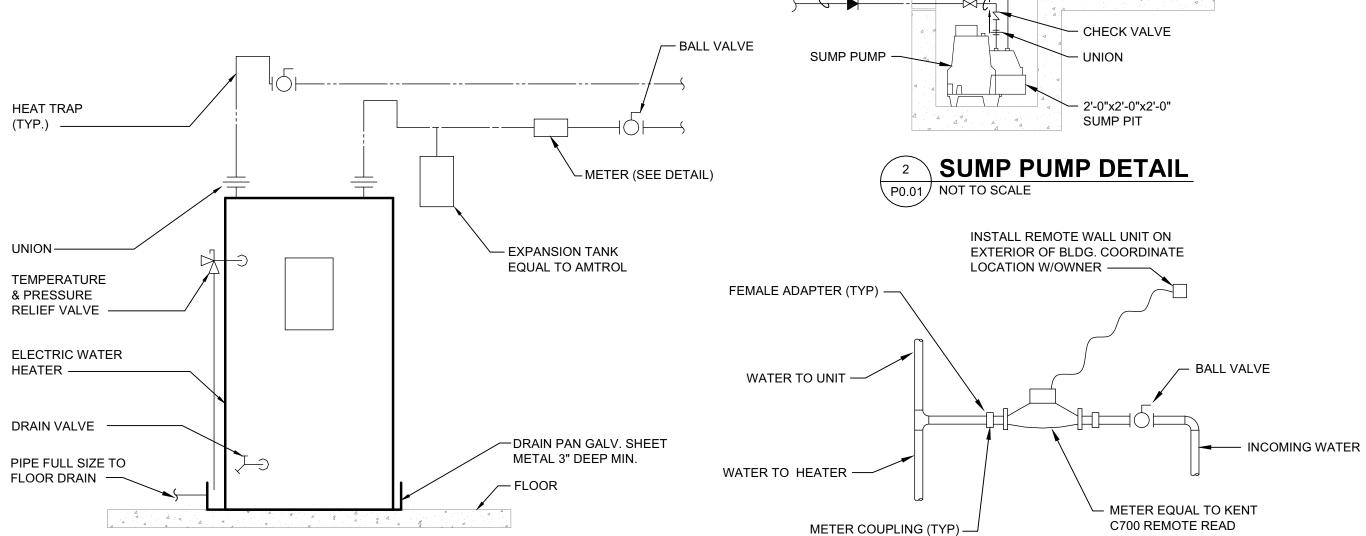

ELECTRIC WATER HEATER DIAGRAM

P0.01 NOT TO SCALE

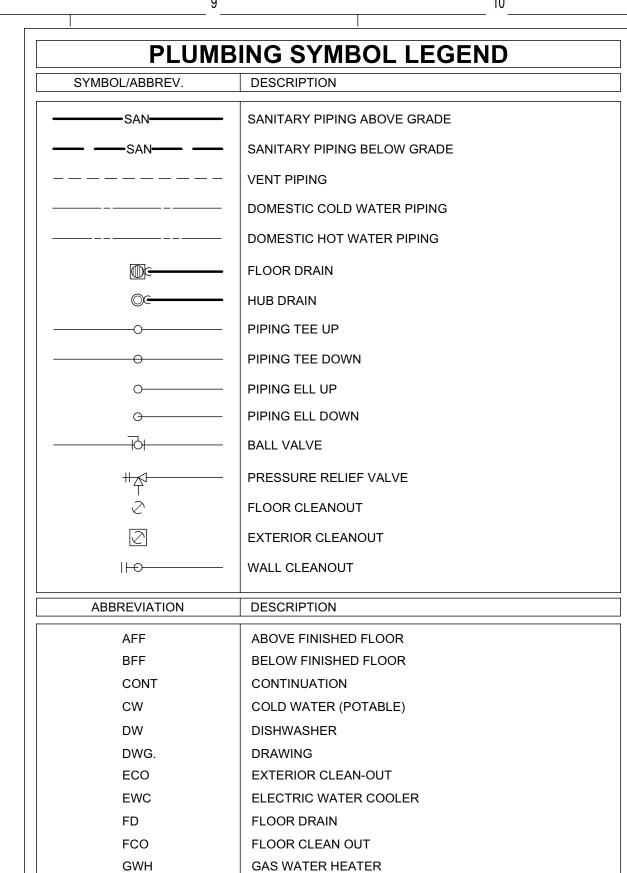

GENERAL NOTES:

— JUNCTION BOX AND WIRING

BY DIVISION 16000

PIT FLOOR -

- GRATING

WATER METER DETAIL

P0.01 NOT TO SCALE

HW HWRP

O.F.C.I.

SA

SAN

T&P

UNO

UB-1

WCO

WH WSB

1. FIELD VERIFY ALL MEASUREMENTS PRIOR TO LAYING AND CONNECTING ANY PIPING, NOTIFY ARCHITECT OF ANY DISCREPANCIES.

HOSE BIBB
HANDICAPPED
HOT WATER

JANITOR SINK

SHOCK ARRESTOR

LAVATORY

UTILITY BOX

WATER CLOSET

WALL CLEAN-OUT
WALL HYDRANT

WASHER SUPPLY BOX

HOT WATER RECIRC. PUMP

UNLESS NOTED OTHERWISE


VACUUM RELIEF VALVE

OWNER FURNISHED CONTRACTOR INSTALLED

TEMPERATURE & PRESSURE RELIEF LINE

- 2. PROVIDE SHOCK ARRESTORS FOR PREVENTING WATER HAMMER AT EACH BATTERY OF FIXTURES ON THE COLD AND HOT WATER SUPPLIES.
 PROVIDE SHOCK ARRESTORS AT ISOLATED PLUMBING FIXTURES. SHOCK ARRESTORS SHALL BE FACTORY FABRICATED AND LOCATED FULLY ACCESSIBLE. SHOCK ARRESTORS SHALL BE SIZED PER PLUMBING AND DRAINAGE INSTITUTE STANDARD WH-201. AIR CHAMBERS ARE NOT
- 3. MAINTAIN FIRE RATING AND WEATHERPROOFING INTEGRITY OF ALL PIPING PENETRATIONS.
- 4. ROUTE ALL PIPING CONCEALED ABOVE CEILINGS WITHIN WALLS OR IN CHASES EXCEPT AS SPECIFICALLY NOTED.
- PROVIDE ACCESS PANELS TO ALL VALVES WITHIN CHASES OR ABOVE NON-ACCESSIBLE CEILINGS, SEE ARCHITECTURAL DRAWINGS FOR CEILING TYPES.
- 6. SEE ARCHITECTURAL DRAWINGS FOR EXACT LOCATIONS OF PLUMBING FIXTURE MOUNTING HEIGHTS AND DIMENSIONS. DO NOT SCALE DRAWINGS. DRAWINGS ARE DIAGRAMATIC AND ARE INTENDED TO SHOW GENERAL
- 7. VERIFY ELEVATIONS OF SEWER PIPING TO WHICH NEW SEWERS ARE TO BE CONNECTED PRIOR TO INSTALLATION OF ANY PIPING.
- 8. PROVIDE DIELECTRIC UNIONS AT CONNECTIONS OF DISSIMILAR METALS.
- 9. THE CONTRACTOR IS EXPECTED TO ORDER MATERIALS IN SUFFICIENT TIME TO AVOID DELAYING THE COMPLETION OF THE PROJECT. DELAY IN DELIVERIES WILL NOT BE CONSIDERED A JUSTIFIABLE REASON FOR SUBSTITUTION OF MATERIALS.
- 10. 2014 FLORIDA PLUMBING CODE.

SHOCK ARRESTOR SCHEDULE					
P.D.I. SIZE	FIXTURE UNITS				
'SA-A'	1-11				

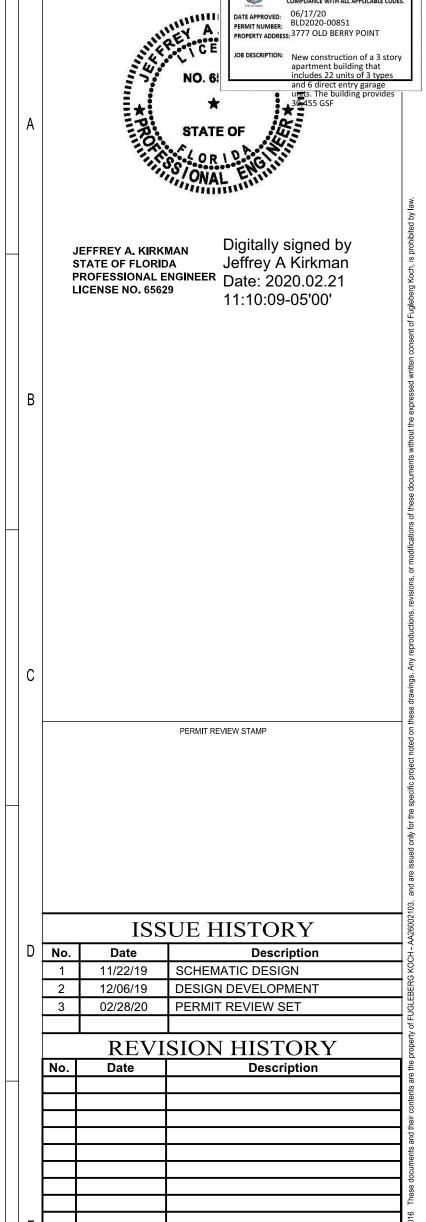

THIS PLAN REVIEWED FOR SUBSTANTIAL CODE





THIS ITEM HAS BEEN ELECTRONICALLY SIGNED AND SEALED BY JEFFREY A. KIRKMAN, PE ON DATE INDICATED IN DIGITAL SIGNATURE USING A DIGITAL SIGNATURE.


PRINTED COPIES OF THIS DOCUMENT ARE NOT CONSIDERED SIGNED AND SEALED AND THE SIGNATURE MUST BE VERIFIED ON ANY ELECTRONIC COPIES.

	Drawn:	SWC
THE DODEDT	Checked:	RDP
THE ROBERT	Approval:	JAK
	Date:	09/10/2019
FT. MYERS, FL	Project #:	5592

LEGEND, SCHEDULES AND NOTES - PLUMBING

P0.01

LOTTED: 2/21/2020

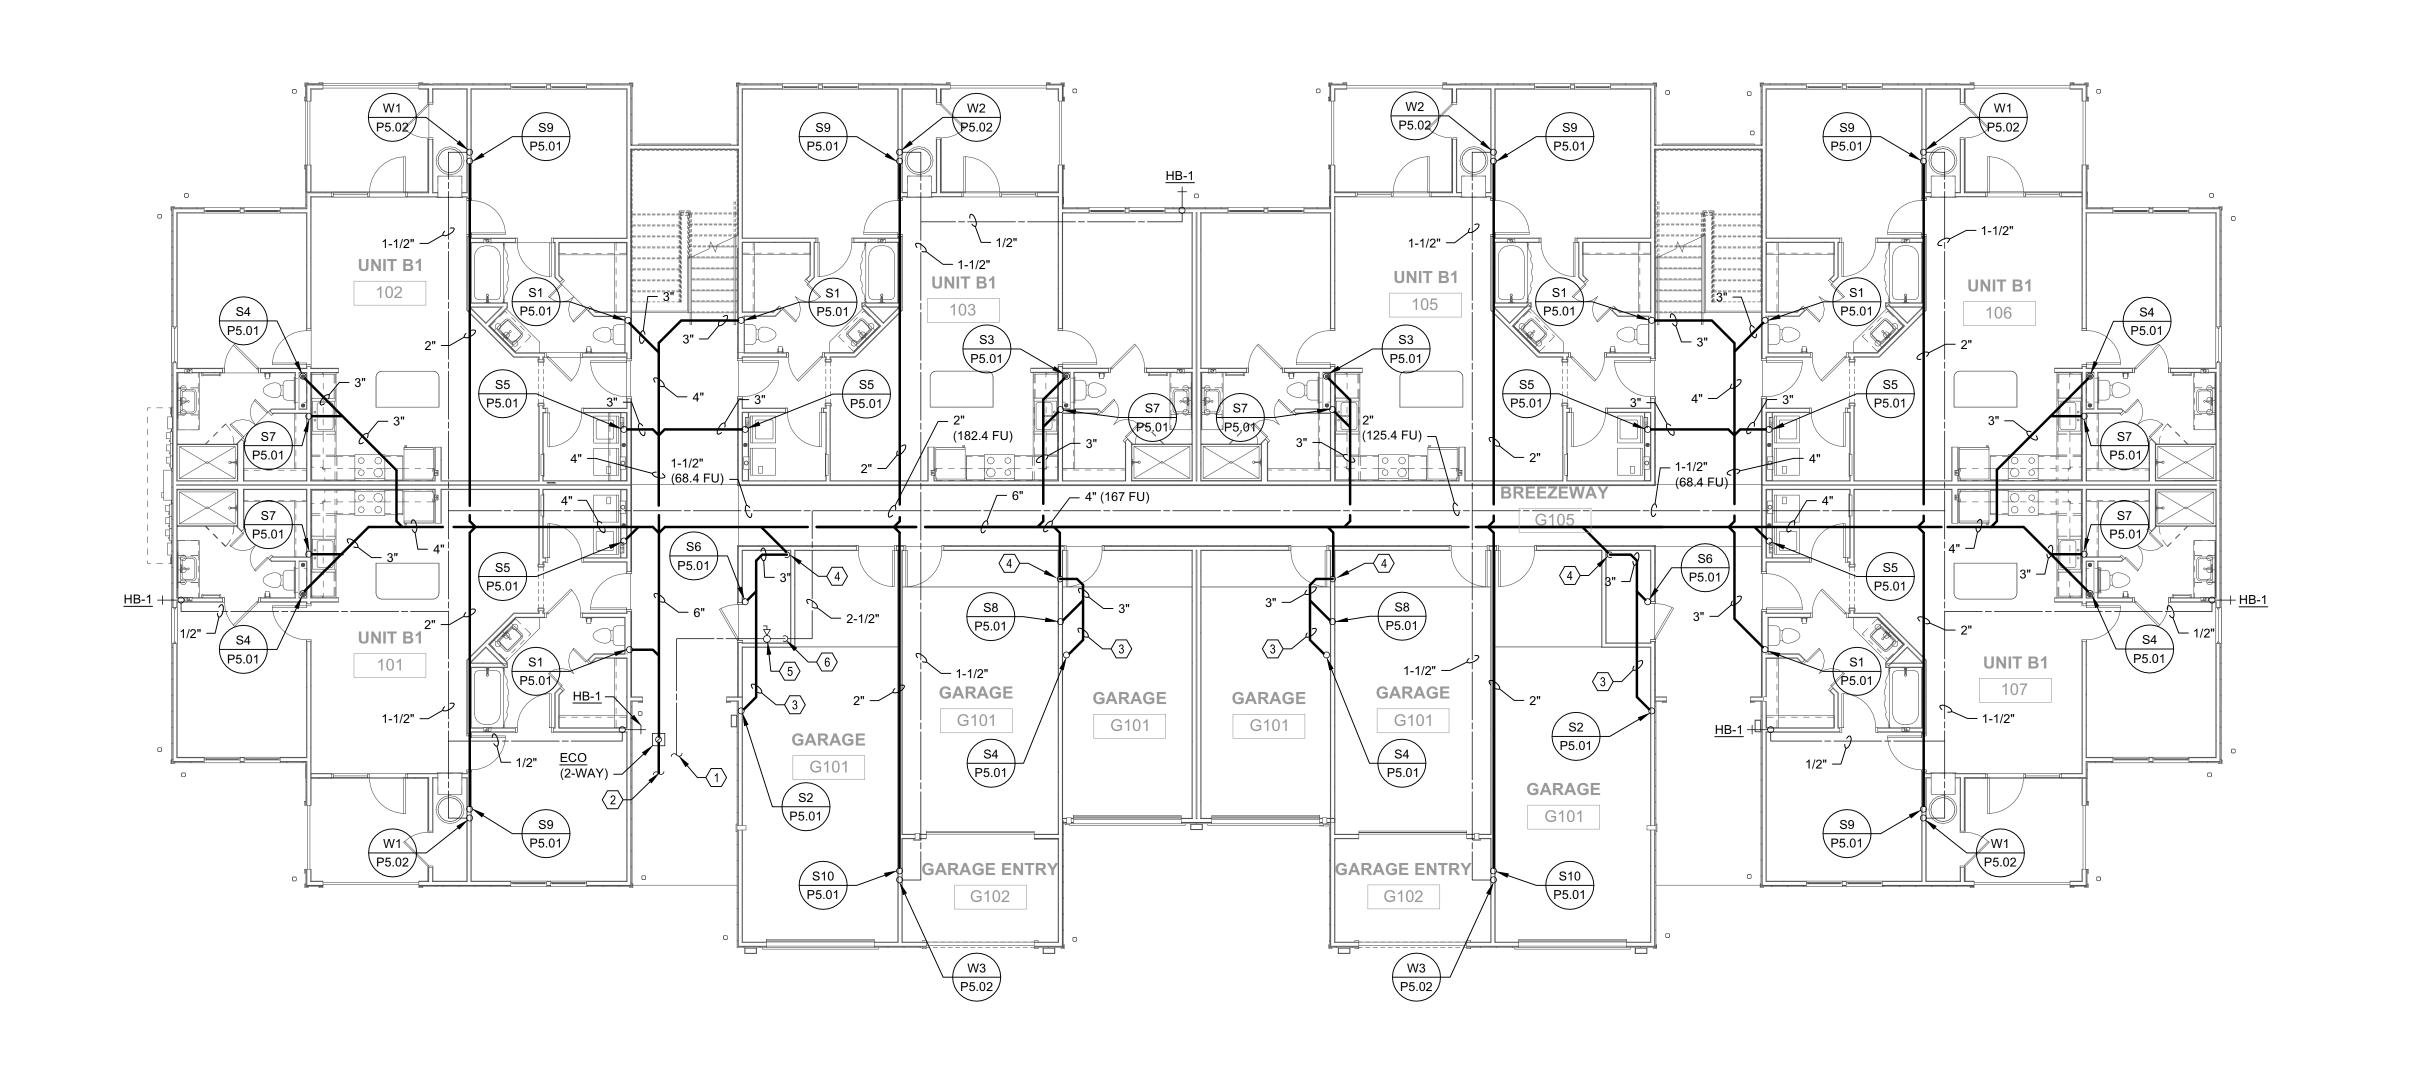

REFERENCE |

COMPLIANCE WITH ALL APPLICABLE

DATE APPROVED: 06/17/20

DATE APPROVED: 06/17/20

PERMIT NUMBER: BLD2020-00851

PROPERTY ADDRESS; 3777 OLD BERRY POINT

VALVE IN VALVE BOX.

TO CIVIL DRAWINGS. (2)

TO CIVIL DRAWINGS. (3)

VALVE IN VALVE BOX.
TO CIVIL DRAWINGS. (;

JOB DESCRIPTION: New construction of a 3 story apartment building that includes 22 units of 3 types and 6 direct entry garage

3 6" SANITARY WASTE PIPING BELOWING TRANSMICTION

5'-0" FROM BUILDING WALL. FOR CONTINUATION REFER TO CIVIL DRAWINGS (327 F.U. INVERT AT

- (3) SANITARY LINE ABOVE GARAGE CEILING.
- (4) SANITARY LINE DOWN TO BELOW SLAB.
- $\langle 5 \rangle$ COLD WATER UP FROM BELOW GRADE. PROVIDE BALL VALVE IN RISER.
- $\langle 6 \rangle$ COLD WATER PIPING DOWN TO BELOW GRADE.

PERMIT REVIEW STAMP

ISSUE HISTORY No. Date Description

1 11/22/19 SCHEMATIC DESIGN
2 12/06/19 DESIGN DEVELOPMENT 02/28/20 PERMIT REVIEW SET **REVISION HISTORY**

Date Description



2555 Temple Trail, Winter Park, FL 32789 (407) 629-0595 www.fuglebergkoch.com BR569



THIS ITEM HAS BEEN ELECTRONICALLY SIGNED AND SEALED BY JEFFREY A. KIRKMAN, PE ON DATE INDICATED IN DIGITAL SIGNATURE USING A DIGITAL SIGNATURE. PRINTED COPIES OF THIS DOCUMENT ARE NOT CONSIDERED SIGNED AND SEALED AND THE SIGNATURE MUST BE VERIFIED ON ANY ELECTRONIC COPIES.

THE ROBERT

09/10/2019 5592


FT. MYERS, FL

BUILDING TYPE 1 - GROUND LEVEL - PLUMBING

P2.01

BUILDING TYPE 1 - GROUND LEVEL - PLUMBING

1/8" = 1'-0"

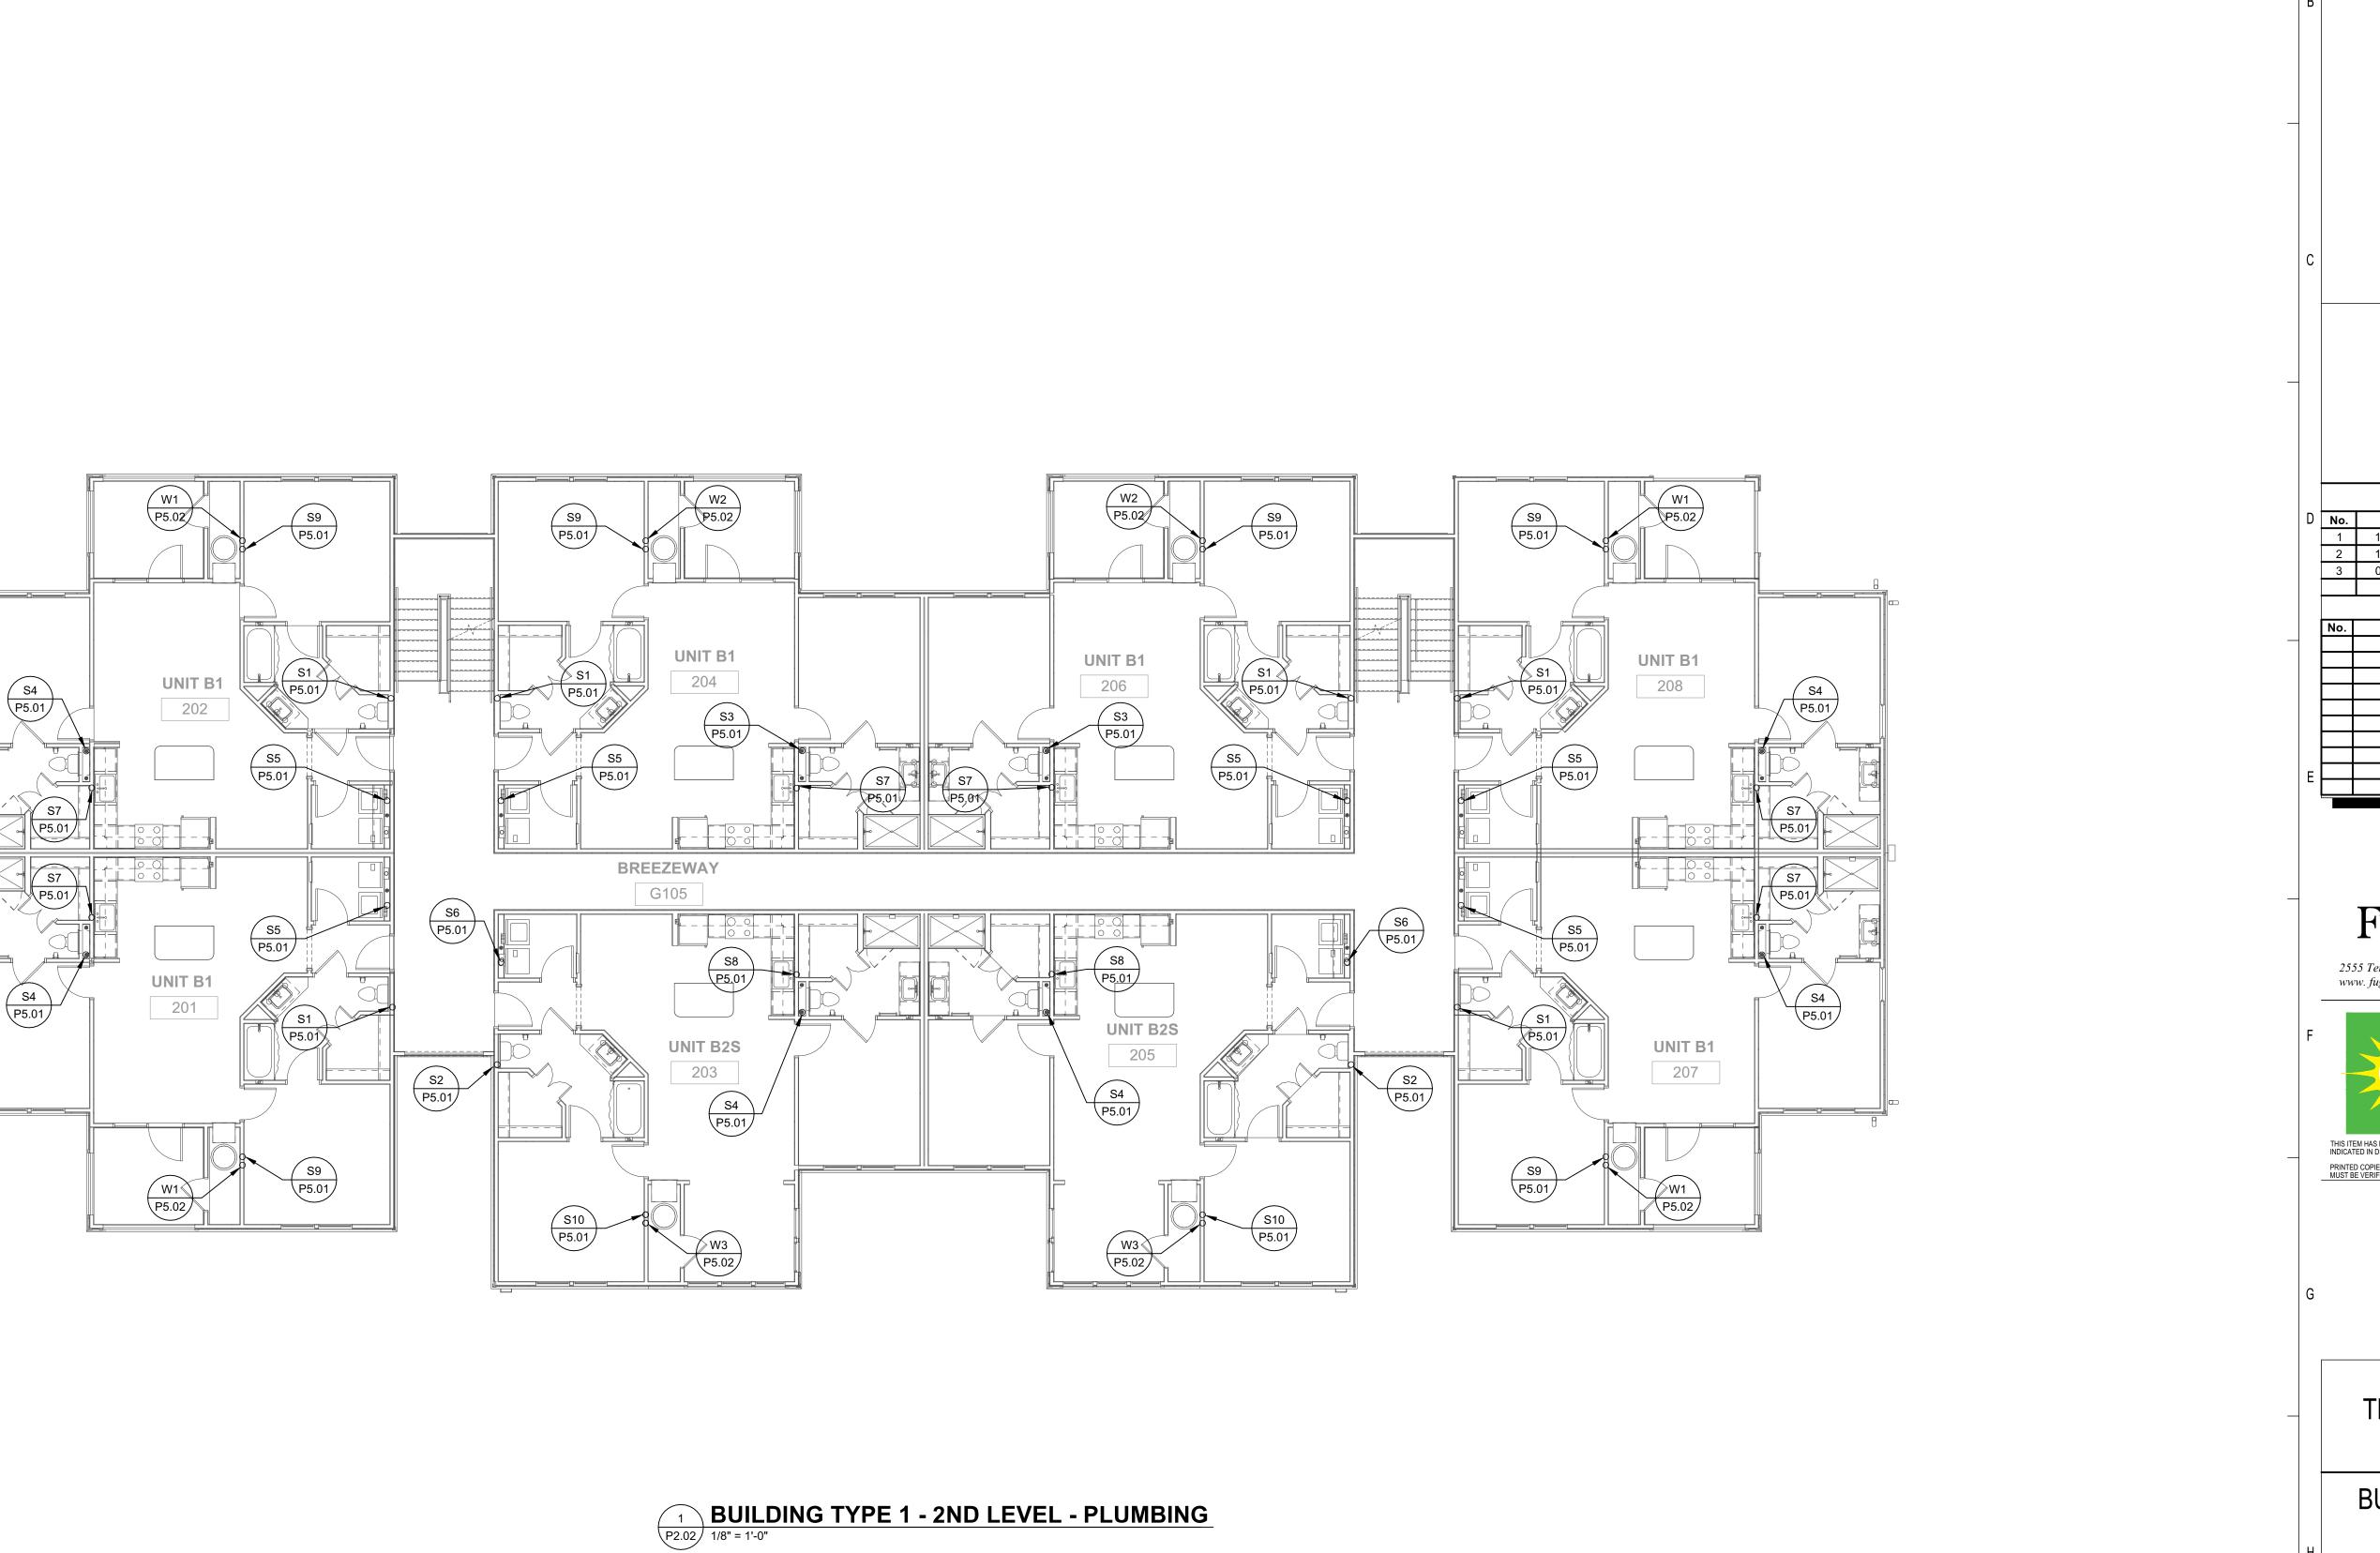

DATE APPROVED: 06/17/20
PERMIT NUMBER: BLD2020-00851
PROPERTY ADDRESS: 3777 OLD BERRY POINT

PERMIT REVIEW STAMP

	ISSUE HISTORY							
No.	Date	Description						
1	11/22/19	SCHEMATIC DESIGN						
2	12/06/19	DESIGN DEVELOPMENT						
3	02/28/20	PERMIT REVIEW SET						
REVISION HISTORY								
No.	Date	Description						






19962 THIS ITEM HAS BEEN ELECTRONICALLY SIGNED AND SEALED BY JEFFREY A. KIRKMAN, PE ON DATE INDICATED IN DIGITAL SIGNATURE USING A DIGITAL SIGNATURE. PRINTED COPIES OF THIS DOCUMENT ARE NOT CONSIDERED SIGNED AND SEALED AND THE SIGNATURE MUST BE VERIFIED ON ANY ELECTRONIC COPIES.

THE ROBERT

09/10/2019 5592 FT. MYERS, FL

BUILDING TYPE 1 - 2ND LEVEL - PLUMBING

P2.02

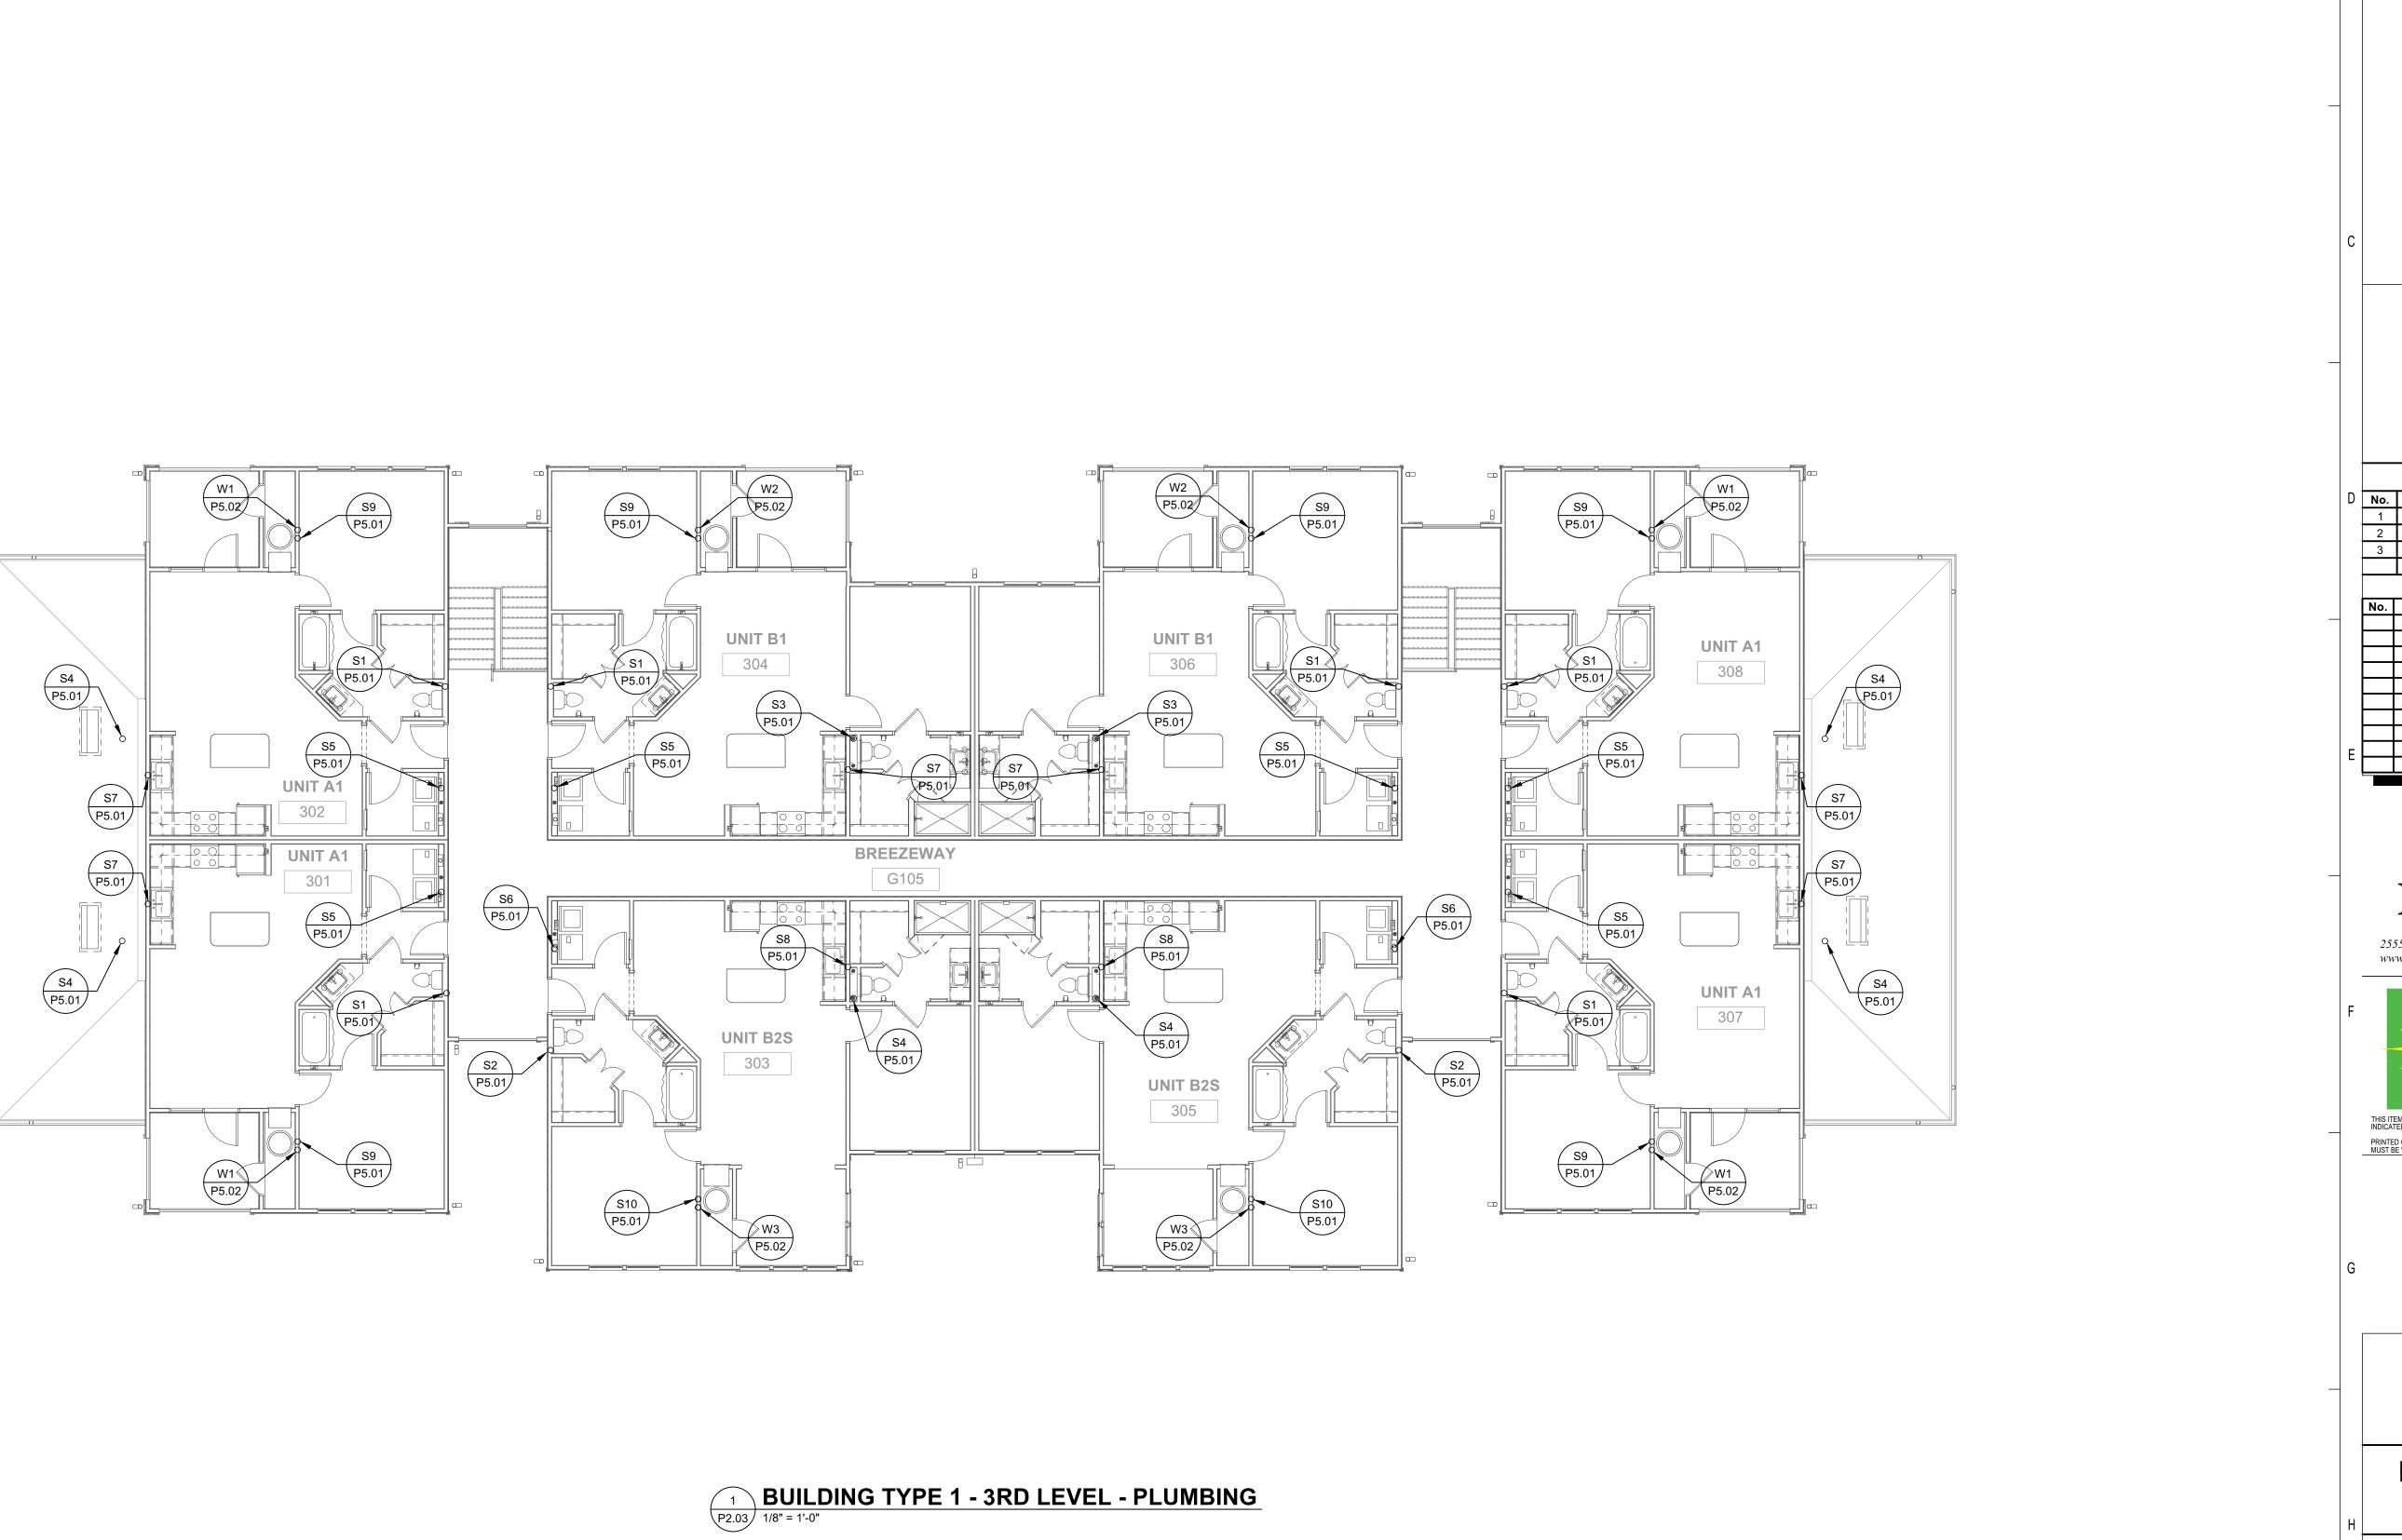

CITY OF FORT MYERS

THIS PLAN REVIEWED FOR SUBSTANTIAL CODE COMPLIANCE WITH ALL APPLICABLE CODES. DATE APPROVED: 06/17/20
PERMIT NUMBER: BLD2020-00851
PROPERTY ADDRESS: 3777 OLD BERRY POINT

ISSUE HISTORY Description 1 11/22/19 SCHEMATIC DESIGN
2 12/06/19 DESIGN DEVELOPMENT REVISION HISTORY Date Description

PERMIT REVIEW STAMP






THIS ITEM HAS BEEN ELECTRONICALLY SIGNED AND SEALED BY JEFFREY A. KIRKMAN, PE ON DATE INDICATED IN DIGITAL SIGNATURE USING A DIGITAL SIGNATURE. PRINTED COPIES OF THIS DOCUMENT ARE NOT CONSIDERED SIGNED AND SEALED AND THE SIGNATURE MUST BE VERIFIED ON ANY ELECTRONIC COPIES.

THE ROBERT

FT. MYERS, FL

BUILDING TYPE 1 - 3RD LEVEL - PLUMBING

P2.03

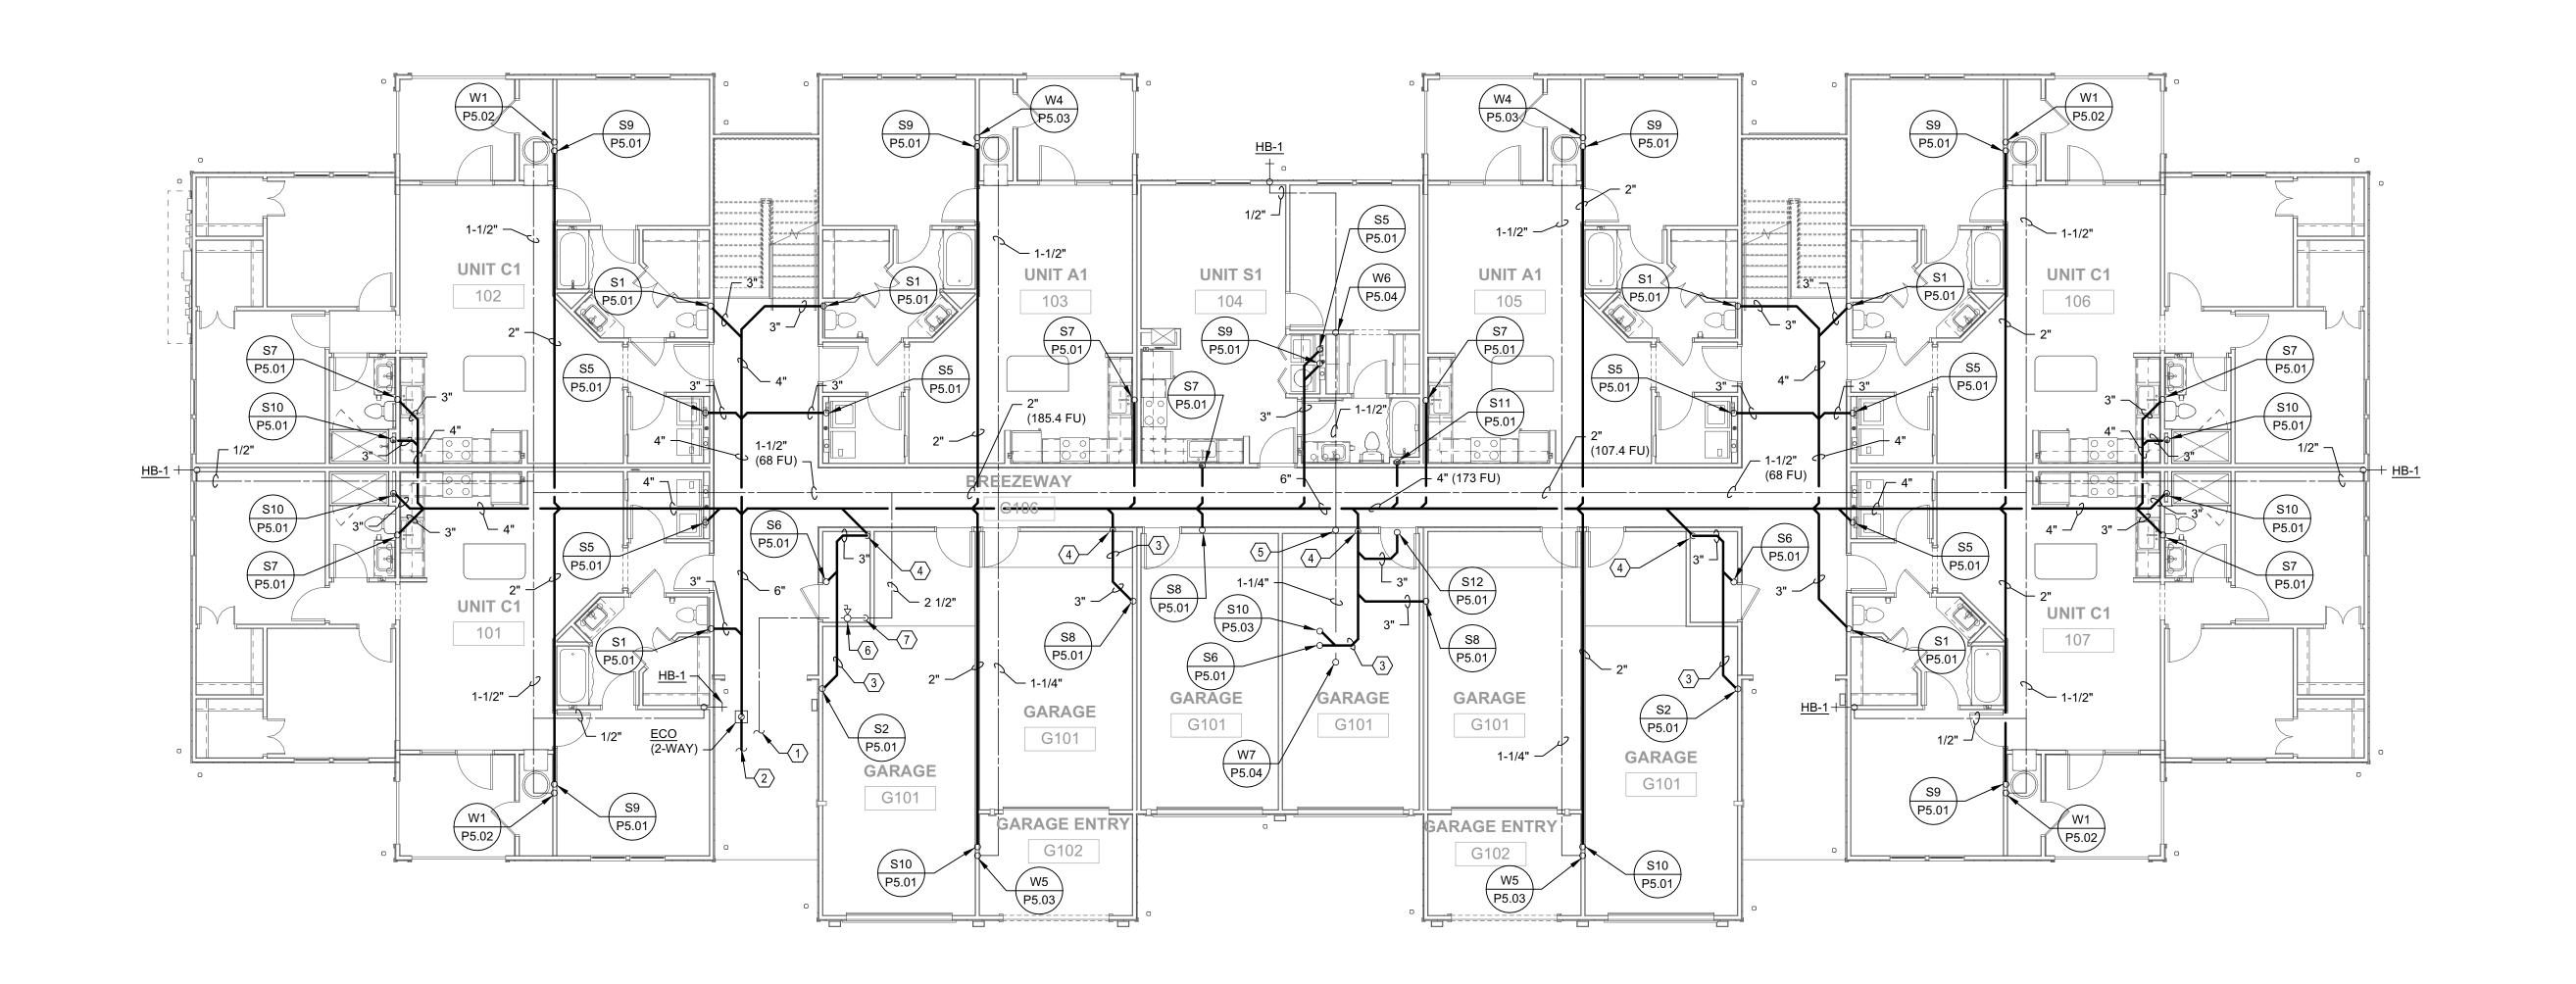

REFERENCE I

1 2 -1/2" DOMESTIC WAT VALVE IN VALVE BOX.
TO CIVIL DRAWINGS.

- VALVE IN VALVE BOX.
 TO CIVIL DRAWINGS. (;

 JOB DESCRIPTION: New construction of a 3 story apartment building that includes 22 units of 3 types and 6 direct entry garage

 2 6" SANITARY WASTE PIPING BELOWING TRANSMICTION

 5'-0" FROM BUILDING WALL. FOR CONTINUATION REFER TO CIVIL DRAWINGS (303 F.U. INVERT AT
- (3) SANITARY LINE ABOVE GARAGE CEILING.
- 4 SANITARY LINE DOWN TO BELOW SLAB.
- $\langle 5 \rangle$ COLD WATER UP FROM BELOW GRADE. PROVIDE BALL VALVE IN RISER.
- $\langle 6 \rangle$ COLD WATER PIPING DOWN TO BELOW GRADE.

ISSUE HISTORY No. Date Description 1 11/22/19 SCHEMATIC DESIGN
2 12/06/19 DESIGN DEVELOPMENT PERMIT REVIEW SET **REVISION HISTORY** Date Description

PERMIT REVIEW STAMP





THIS ITEM HAS BEEN ELECTRONICALLY SIGNED AND SEALED BY JEFFREY A. KIRKMAN, PE ON DATE INDICATED IN DIGITAL SIGNATURE USING A DIGITAL SIGNATURE. PRINTED COPIES OF THIS DOCUMENT ARE NOT CONSIDERED SIGNED AND SEALED AND THE SIGNATURE MUST BE VERIFIED ON ANY ELECTRONIC COPIES.

THE ROBERT


FT. MYERS, FL

BUILDING TYPE 2 - GROUND LEVEL - PLUMBING

P2.05

BUILDING TYPE 2 - GROUND LEVEL - PLUMBING

1/8" = 1'-0"

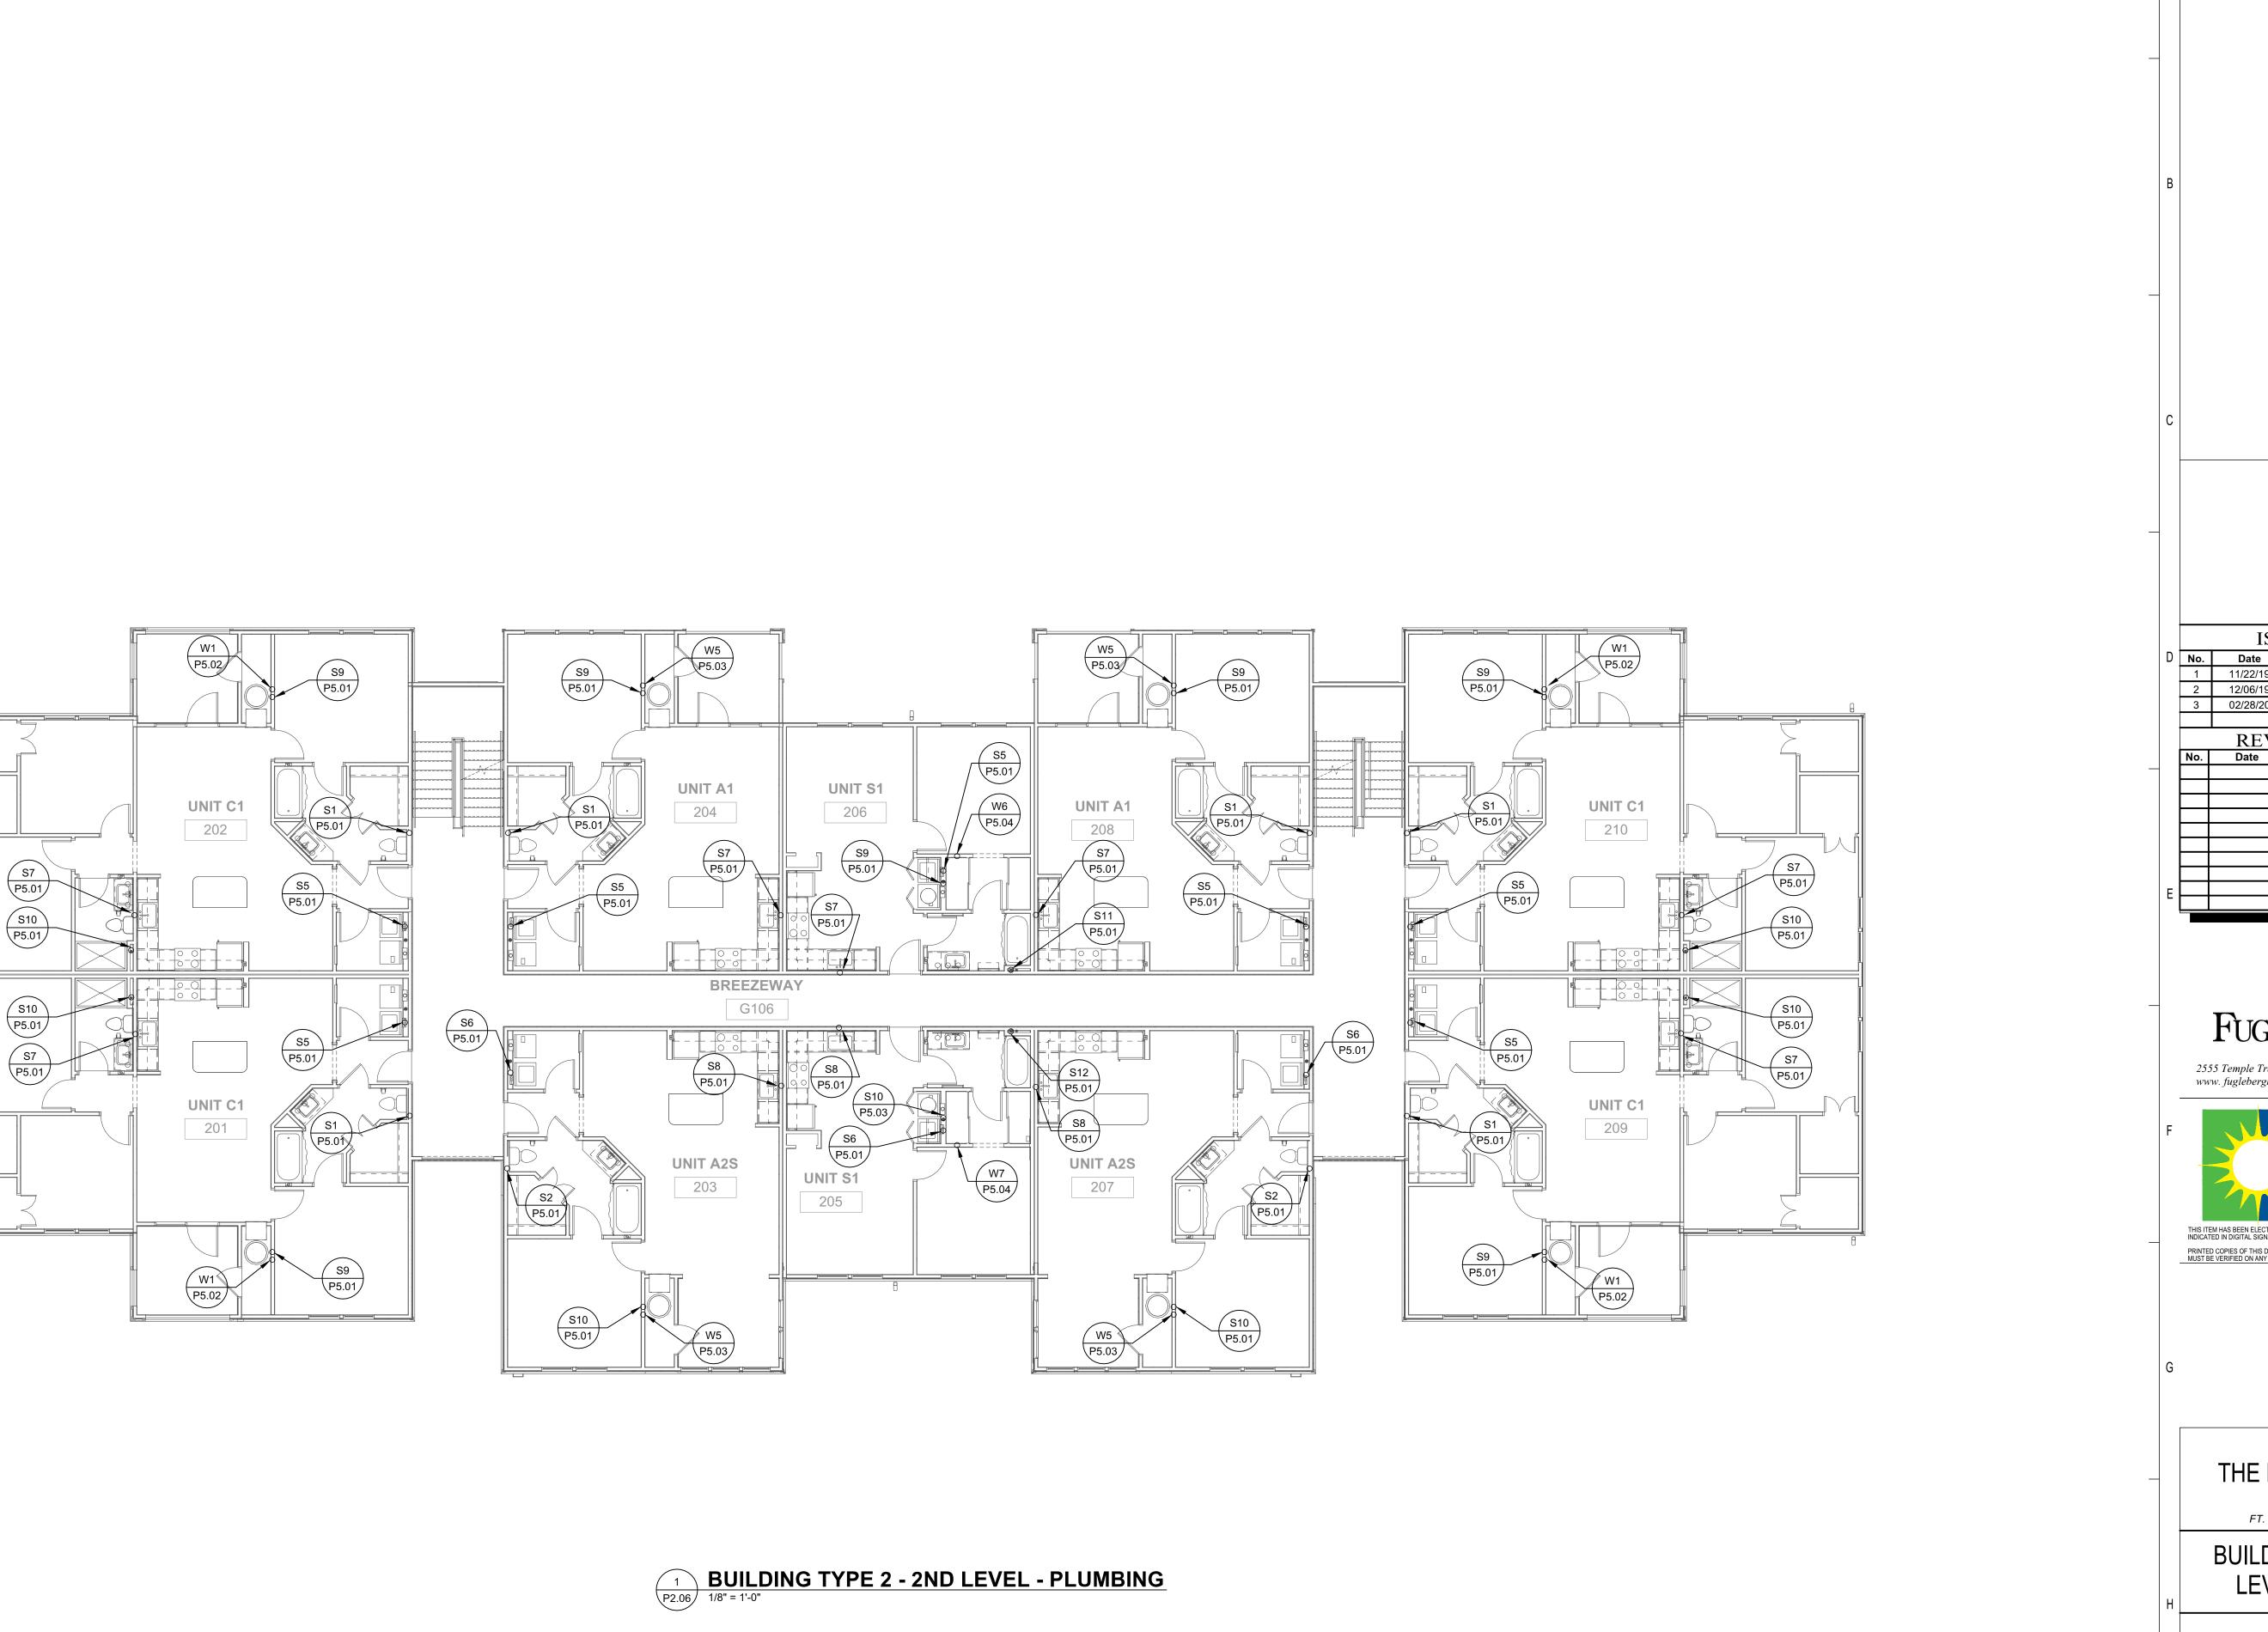

CITY OF FORT MYERS

THIS PLAN REVIEWED FOR SUBSTANTIAL CODE COMPLIANCE WITH ALL APPLICABLE CODES.

DATE APPROVED: 06/17/20
PERMIT NUMBER: BLD2020-00851
PROPERTY ADDRESS: 3777 OLD BERRY POINT

JOB DESCRIPTION: New construction of a 3 story apartment building that includes 22 units of 3 types and 6 direct entry garage units. The building provides 30,455 GSF

 ISSUE HISTORY

 Io.
 Date
 Description

 1
 11/22/19
 SCHEMATIC DESIGN

PERMIT REVIEW STAMP

REVISION HISTORY
No. Date Description

FUGLEBERG KOCH

2555 Temple Trail, Winter Park, FL 32789 (407) 629-0595 www. fuglebergkoch.com BR569



THIS ITEM HAS BEEN ELECTRONICALLY SIGNED AND SEALED BY JEFFREY A. KIRKMAN, PE ON DATE INDICATED IN DIGITAL SIGNATURE USING A DIGITAL SIGNATURE.

PRINTED COPIES OF THIS DOCUMENT ARE NOT CONSIDERED SIGNED AND SEALED AND THE SIGNATURE MUST BE VERIFIED ON ANY ELECTRONIC COPIES.

THE ROBERT

FT. MYERS, FL


Date: 09/10/2019
Project #: 5592

YPE 2 - 2ND

BUILDING TYPE 2 - 2ND LEVEL - PLUMBING

P2.06

07750 0/0//0000

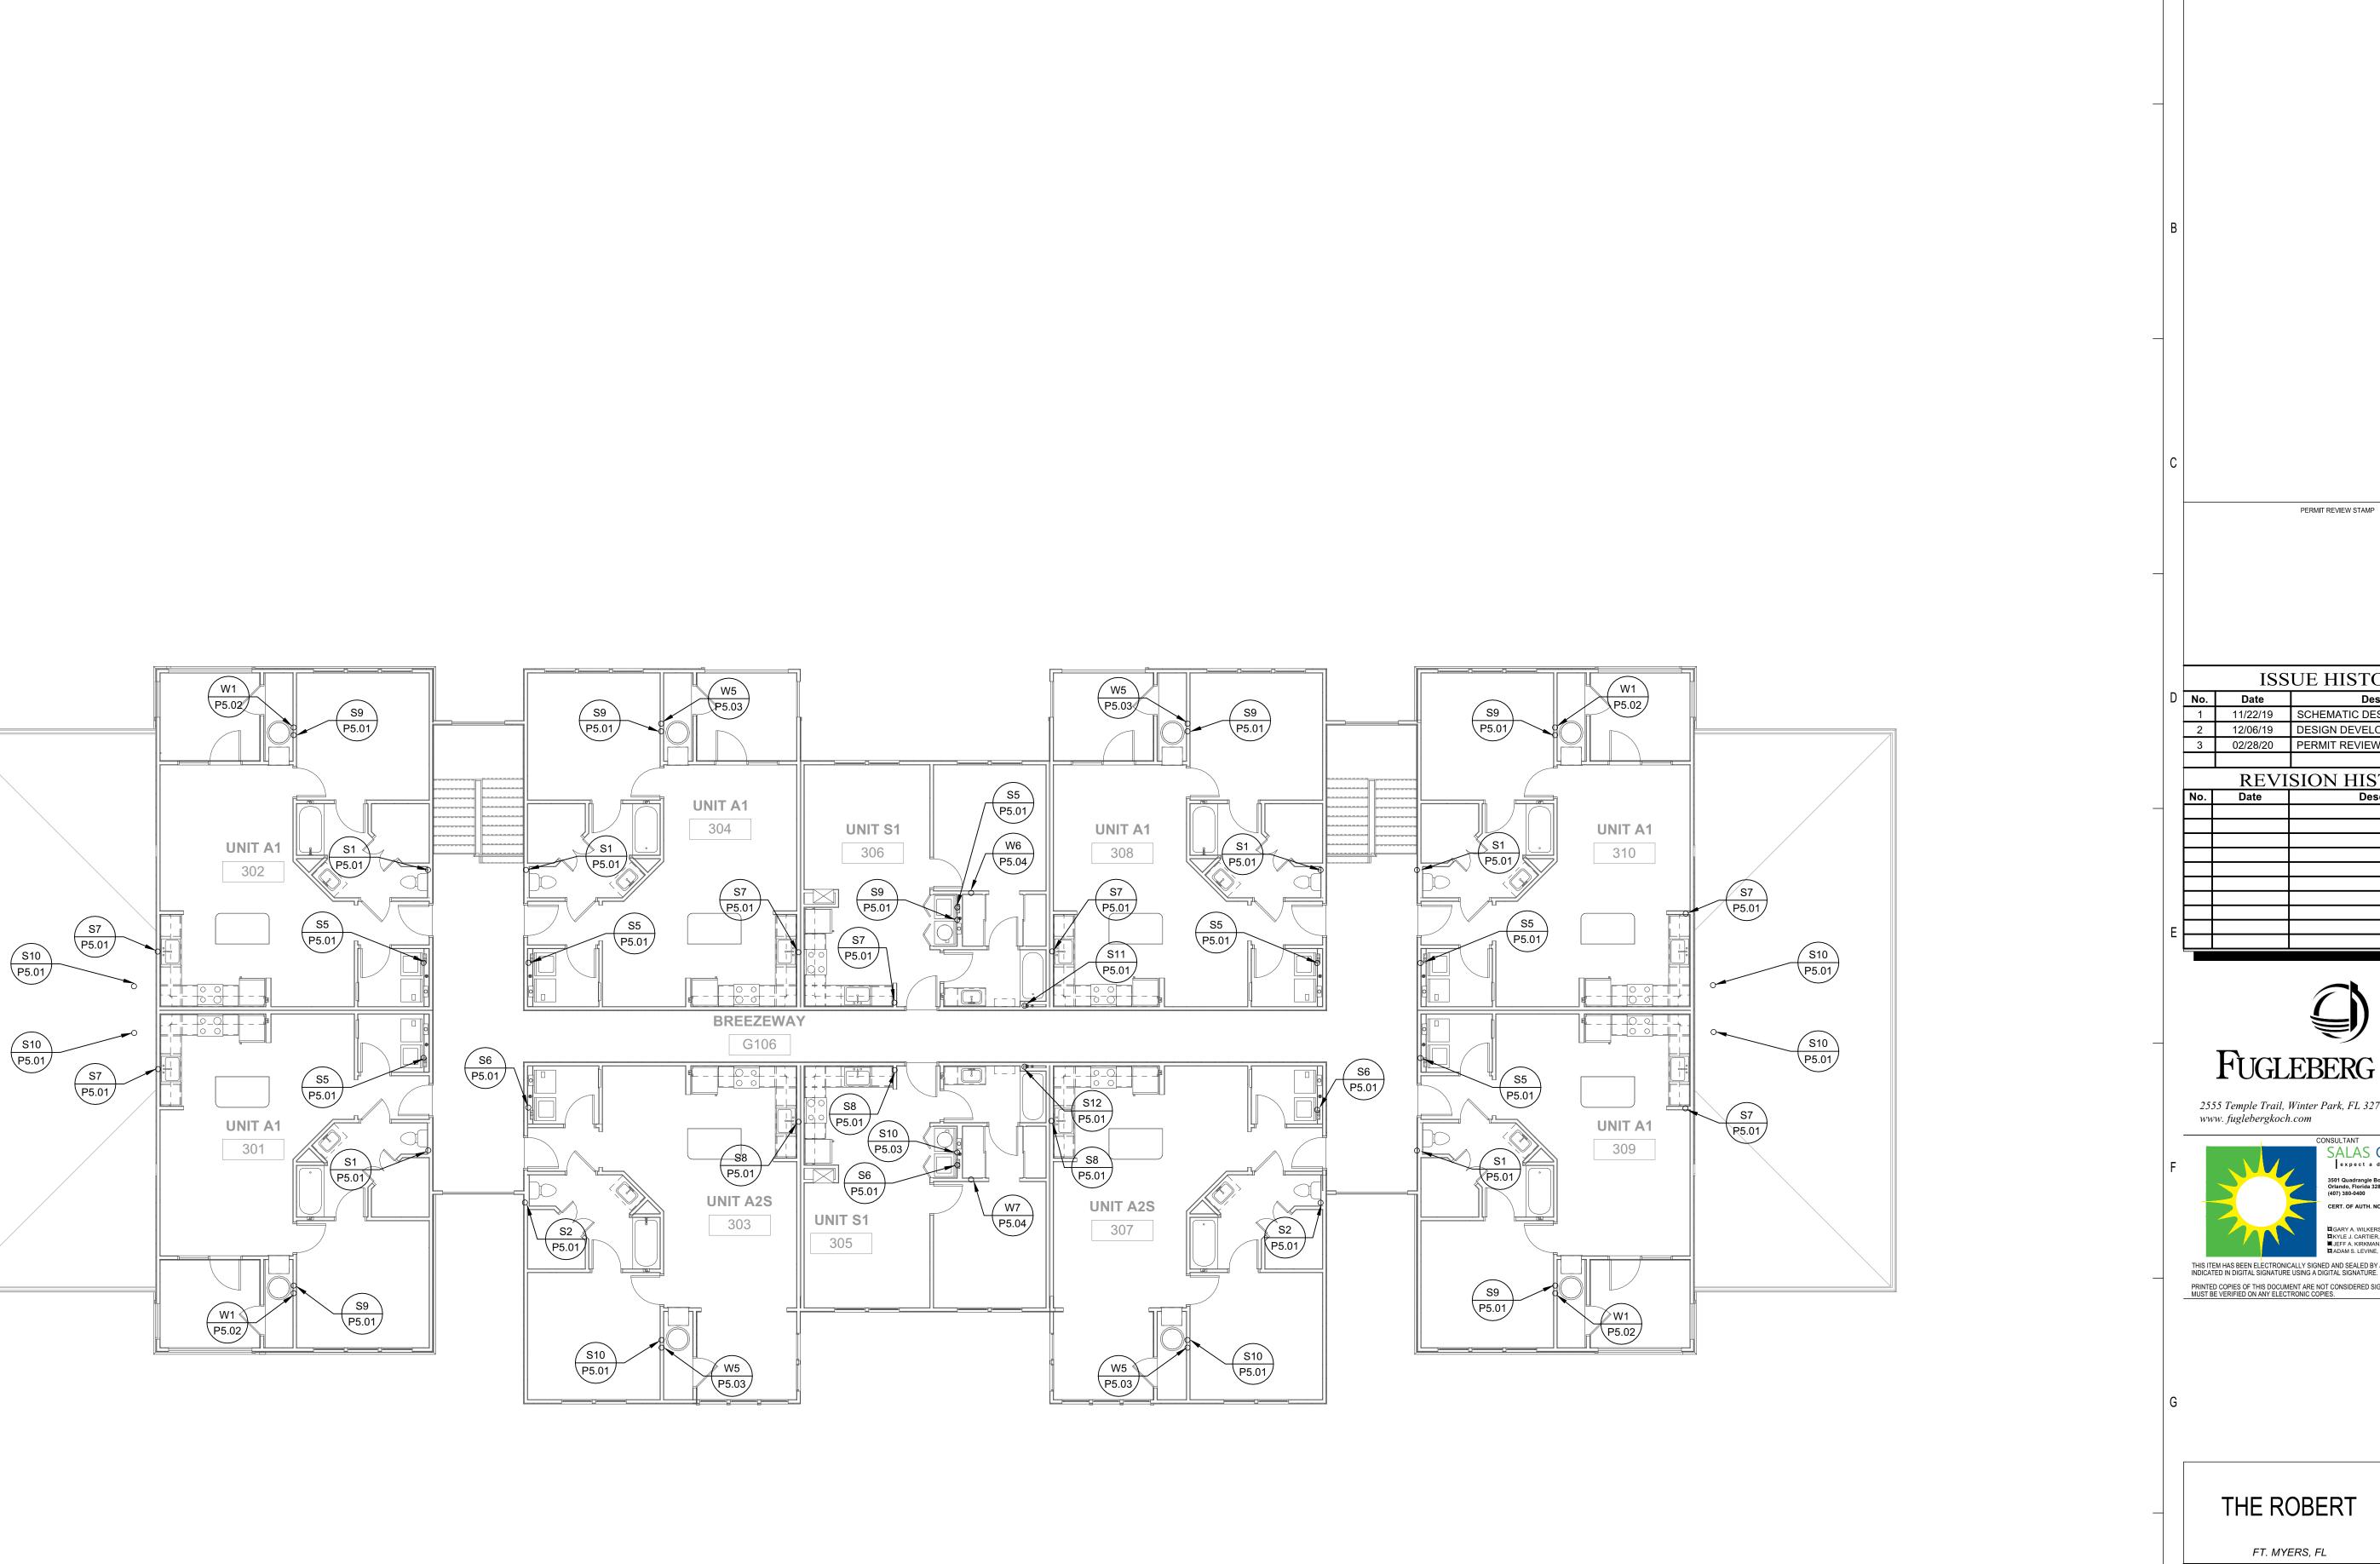

BUILDING TYPE 2 - 3RD LEVEL - PLUMBING

1/8" = 1'-0"

THIS PLAN REVIEWED FOR SUBSTANTIAL CODE COMPLIANCE WITH ALL APPLICABLE CODES. DATE APPROVED: 06/17/20
PERMIT NUMBER: BLD2020-00851
PROPERTY ADDRESS: 3777 OLD BERRY POINT

ISSUE HISTORY Description 1 11/22/19 SCHEMATIC DESIGN
2 12/06/19 DESIGN DEVELOPMENT REVISION HISTORY Description





19962 THIS ITEM HAS BEEN ELECTRONICALLY SIGNED AND SEALED BY JEFFREY A. KIRKMAN, PE ON DATE INDICATED IN DIGITAL SIGNATURE USING A DIGITAL SIGNATURE. PRINTED COPIES OF THIS DOCUMENT ARE NOT CONSIDERED SIGNED AND SEALED AND THE SIGNATURE MUST BE VERIFIED ON ANY ELECTRONIC COPIES.


THE ROBERT

FT. MYERS, FL

BUILDING TYPE 2 - 3RD

LEVEL - PLUMBING

P2.07

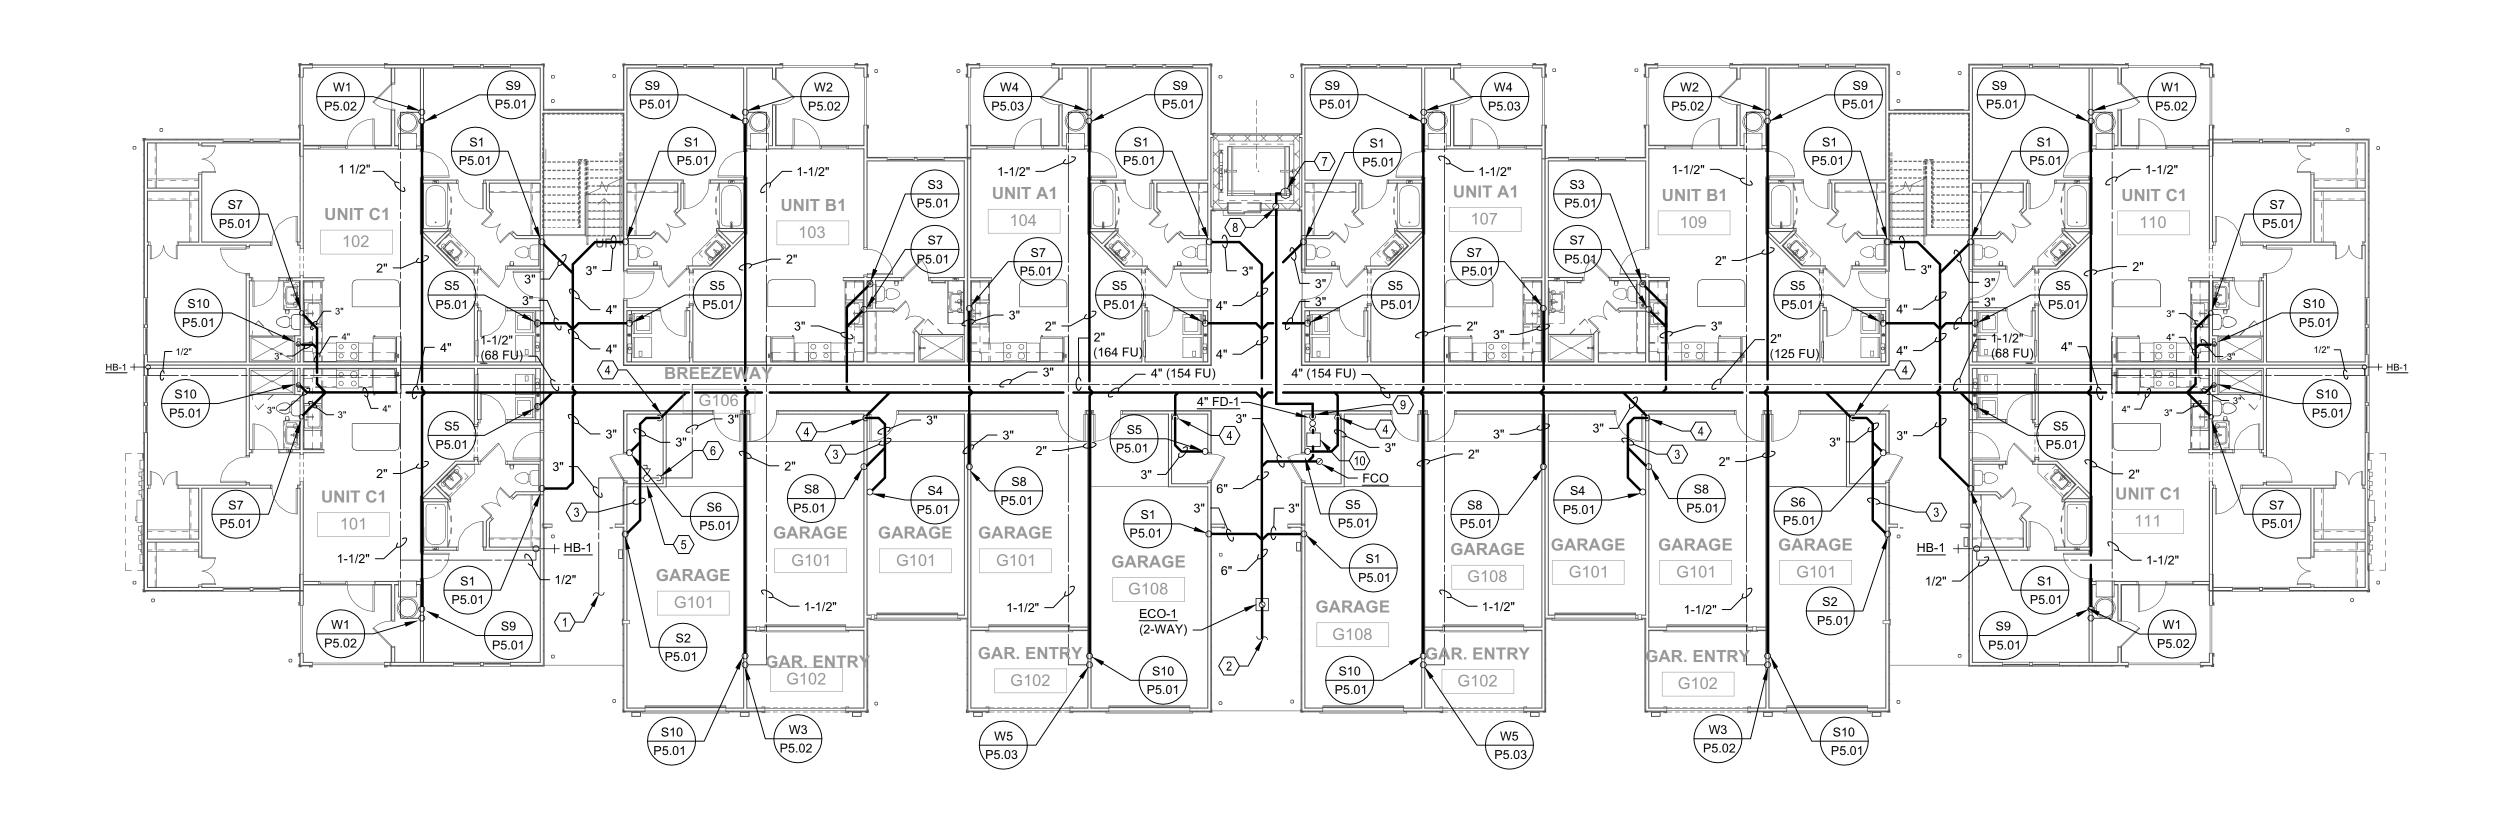

BUILDING TYPE 3 - GROUND LEVEL - PLUMBING

3/32" = 1'-0"

REFERENCE I

VALVE IN VALVE BOX.

THIS PLAN REVIEWED FOR SUBSTANTIAL CODE TEPEREINGE | DATE | DAT

5'-0" FROM BUILDING WALL. FOR CƏNTINUATION REFER TO CIVIL DRAWINGS (398 F.U. INVERT AT

- (3) SANITARY LINE ABOVE GARAGE CEILING.
- 4 SANITARY LINE DOWN TO BELOW SLAB.

BALL VALVE IN RISER.

50 GPM FLOW RATE.

- (5) COLD WATER UP FROM BELOW GRADE. PROVIDE
- $\langle 6 \rangle$ COLD WATER PIPING DOWN TO BELOW GRADE.
- $\langle 7 \rangle$ SUMP PUMP EQUAL TO ZOELLER MODEL 152,
- 50 GPM, 20 FT OF HEAD, 1750 RPM, 1/2 HP, 115V, SINGLE PHASE.
- $\langle 8 \rangle$ 2" SUMP PUMP DISCHARGE UP TO ABOVE THE CEILING.

FINISHED FLOOR. EQUAL TO JOSAM 60508A,

- (9) 2" SUMP PUMP DISCHARGE EXPOSED ON WALL
- AND INDIRECT INTO FLOOR DRAIN. (10) OIL WATER SEPARATOR MOUNTED FLUSH WITH

PERMIT REVIEW STAMP

ISSUE HISTORY

140.	Date	Description	
1	11/22/19	SCHEMATIC DESIGN	
2	12/06/19	DESIGN DEVELOPMENT	
3	02/28/20	PERMIT REVIEW SET	
DEVISION HISTORY			

REVISION HISTORY Date Description



2555 Temple Trail, Winter Park, FL 32789 (407) 629-0595 www. fuglebergkoch.com BR569



CERT. OF AUTH. NO. 6106

19962 THIS ITEM HAS BEEN ELECTRONICALLY SIGNED AND SEALED BY JEFFREY A. KIRKMAN, PE ON DATE INDICATED IN DIGITAL SIGNATURE USING A DIGITAL SIGNATURE. PRINTED COPIES OF THIS DOCUMENT ARE NOT CONSIDERED SIGNED AND SEALED AND THE SIGNATURE MUST BE VERIFIED ON ANY ELECTRONIC COPIES.


THE ROBERT

09/10/2019

FT. MYERS, FL

BUILDING TYPE 3 - GROUND LEVEL - PLUMBING

P2.09

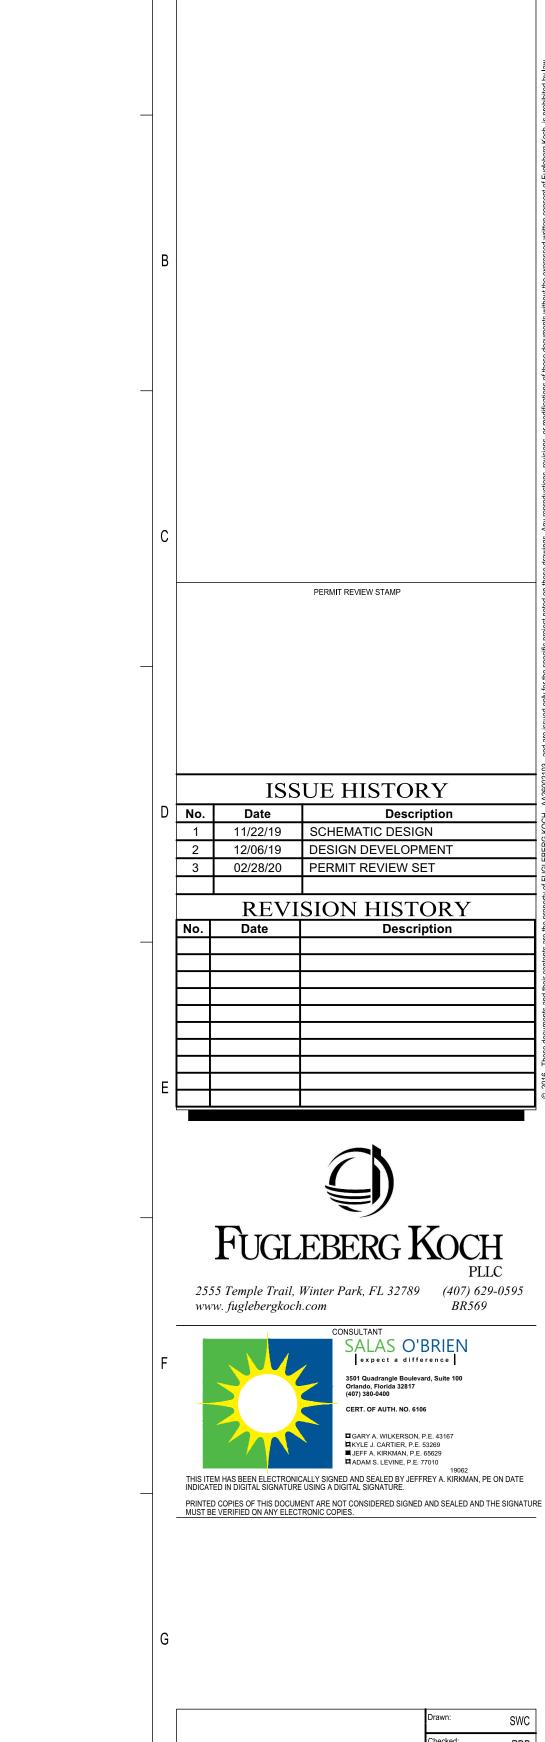


CITY OF FORT MYERS

THIS PLAN REVIEWED FOR SUBSTANTIAL CODE COMPLIANCE WITH ALL APPLICABLE CODES.

DATE APPROVED: 06/17/20
PERMIT NUMBER: BLD2020-00851
PROPERTY ADDRESS: 3777 OLD BERRY POINT

AN New construction of a 3 story apartment building that includes 22 units of 3 types and 6 direct entry garage units. The building provides 30,455 GSF

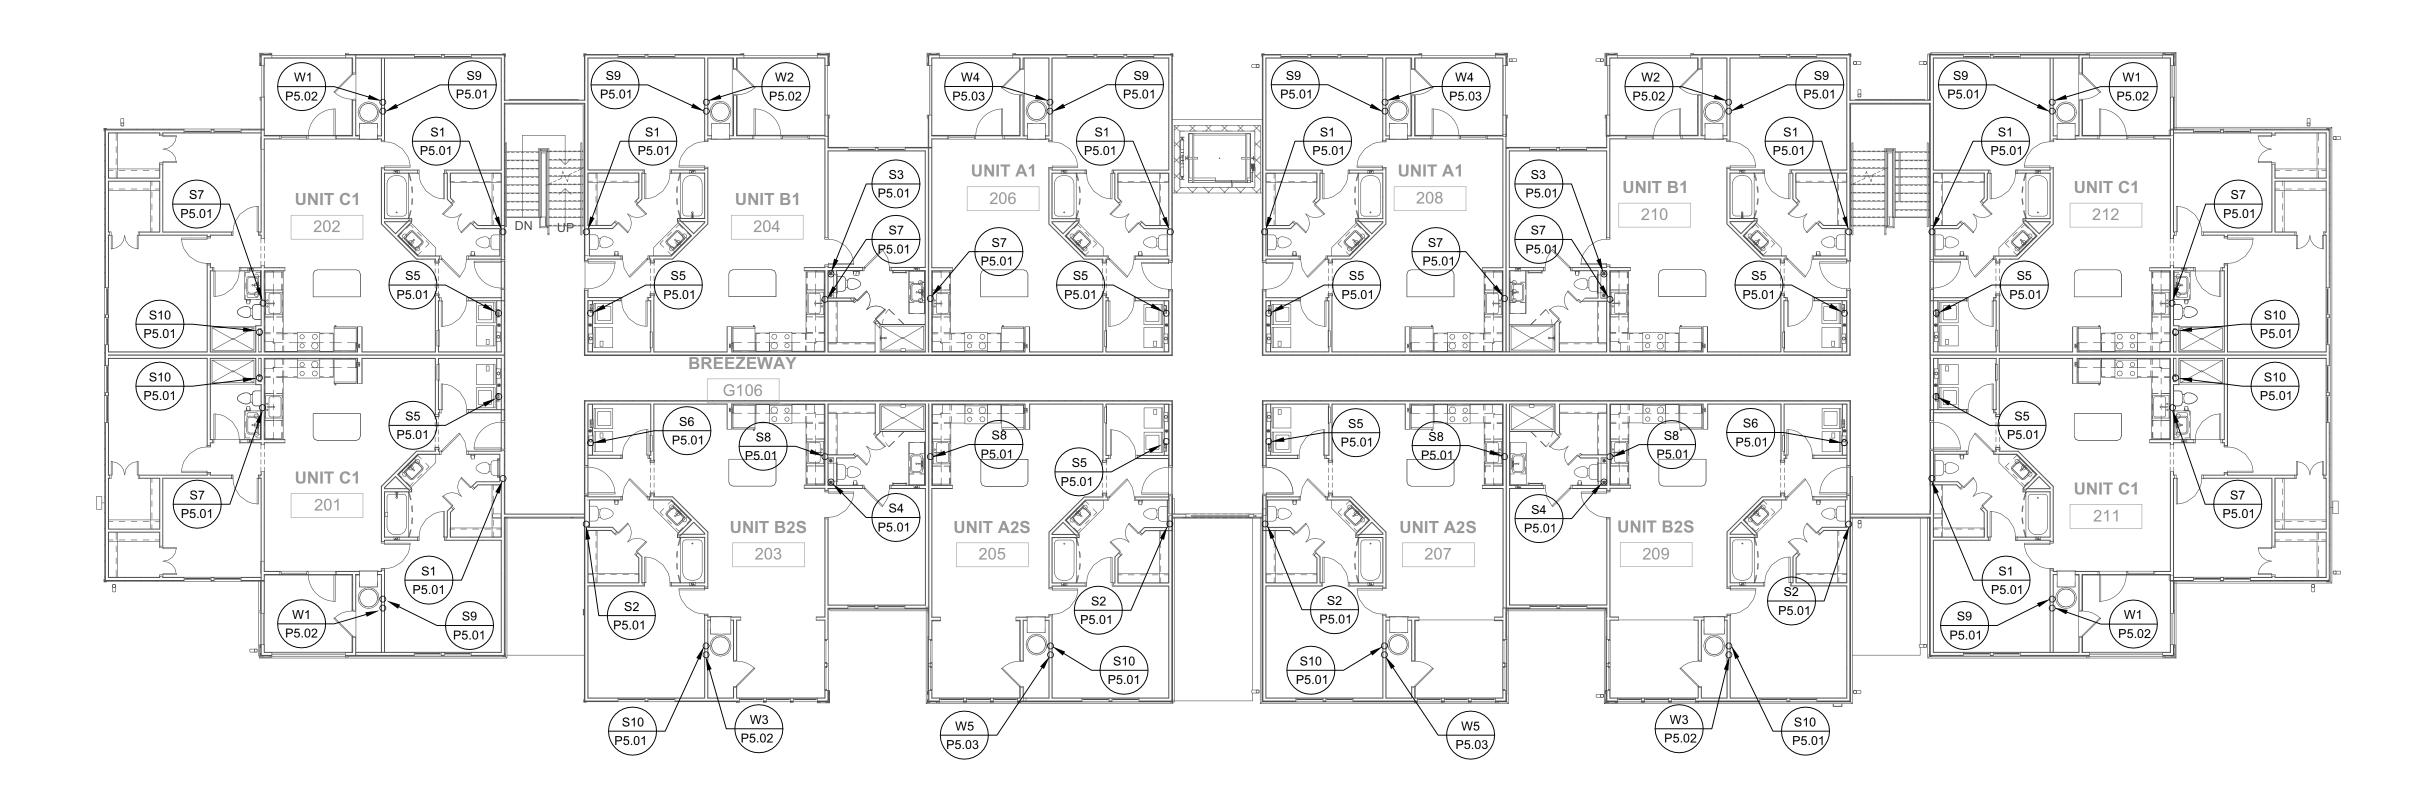

1 BUILDING TYPE 3 - 2ND LEVEL - PLUMBING
P2.10 3/32" = 1'-0"


THE ROBERT

FT. MYERS, FL

BUILDING TYPE 3 - 2ND LEVEL - PLUMBING

P2.10

LOTTED: 2/21/2020

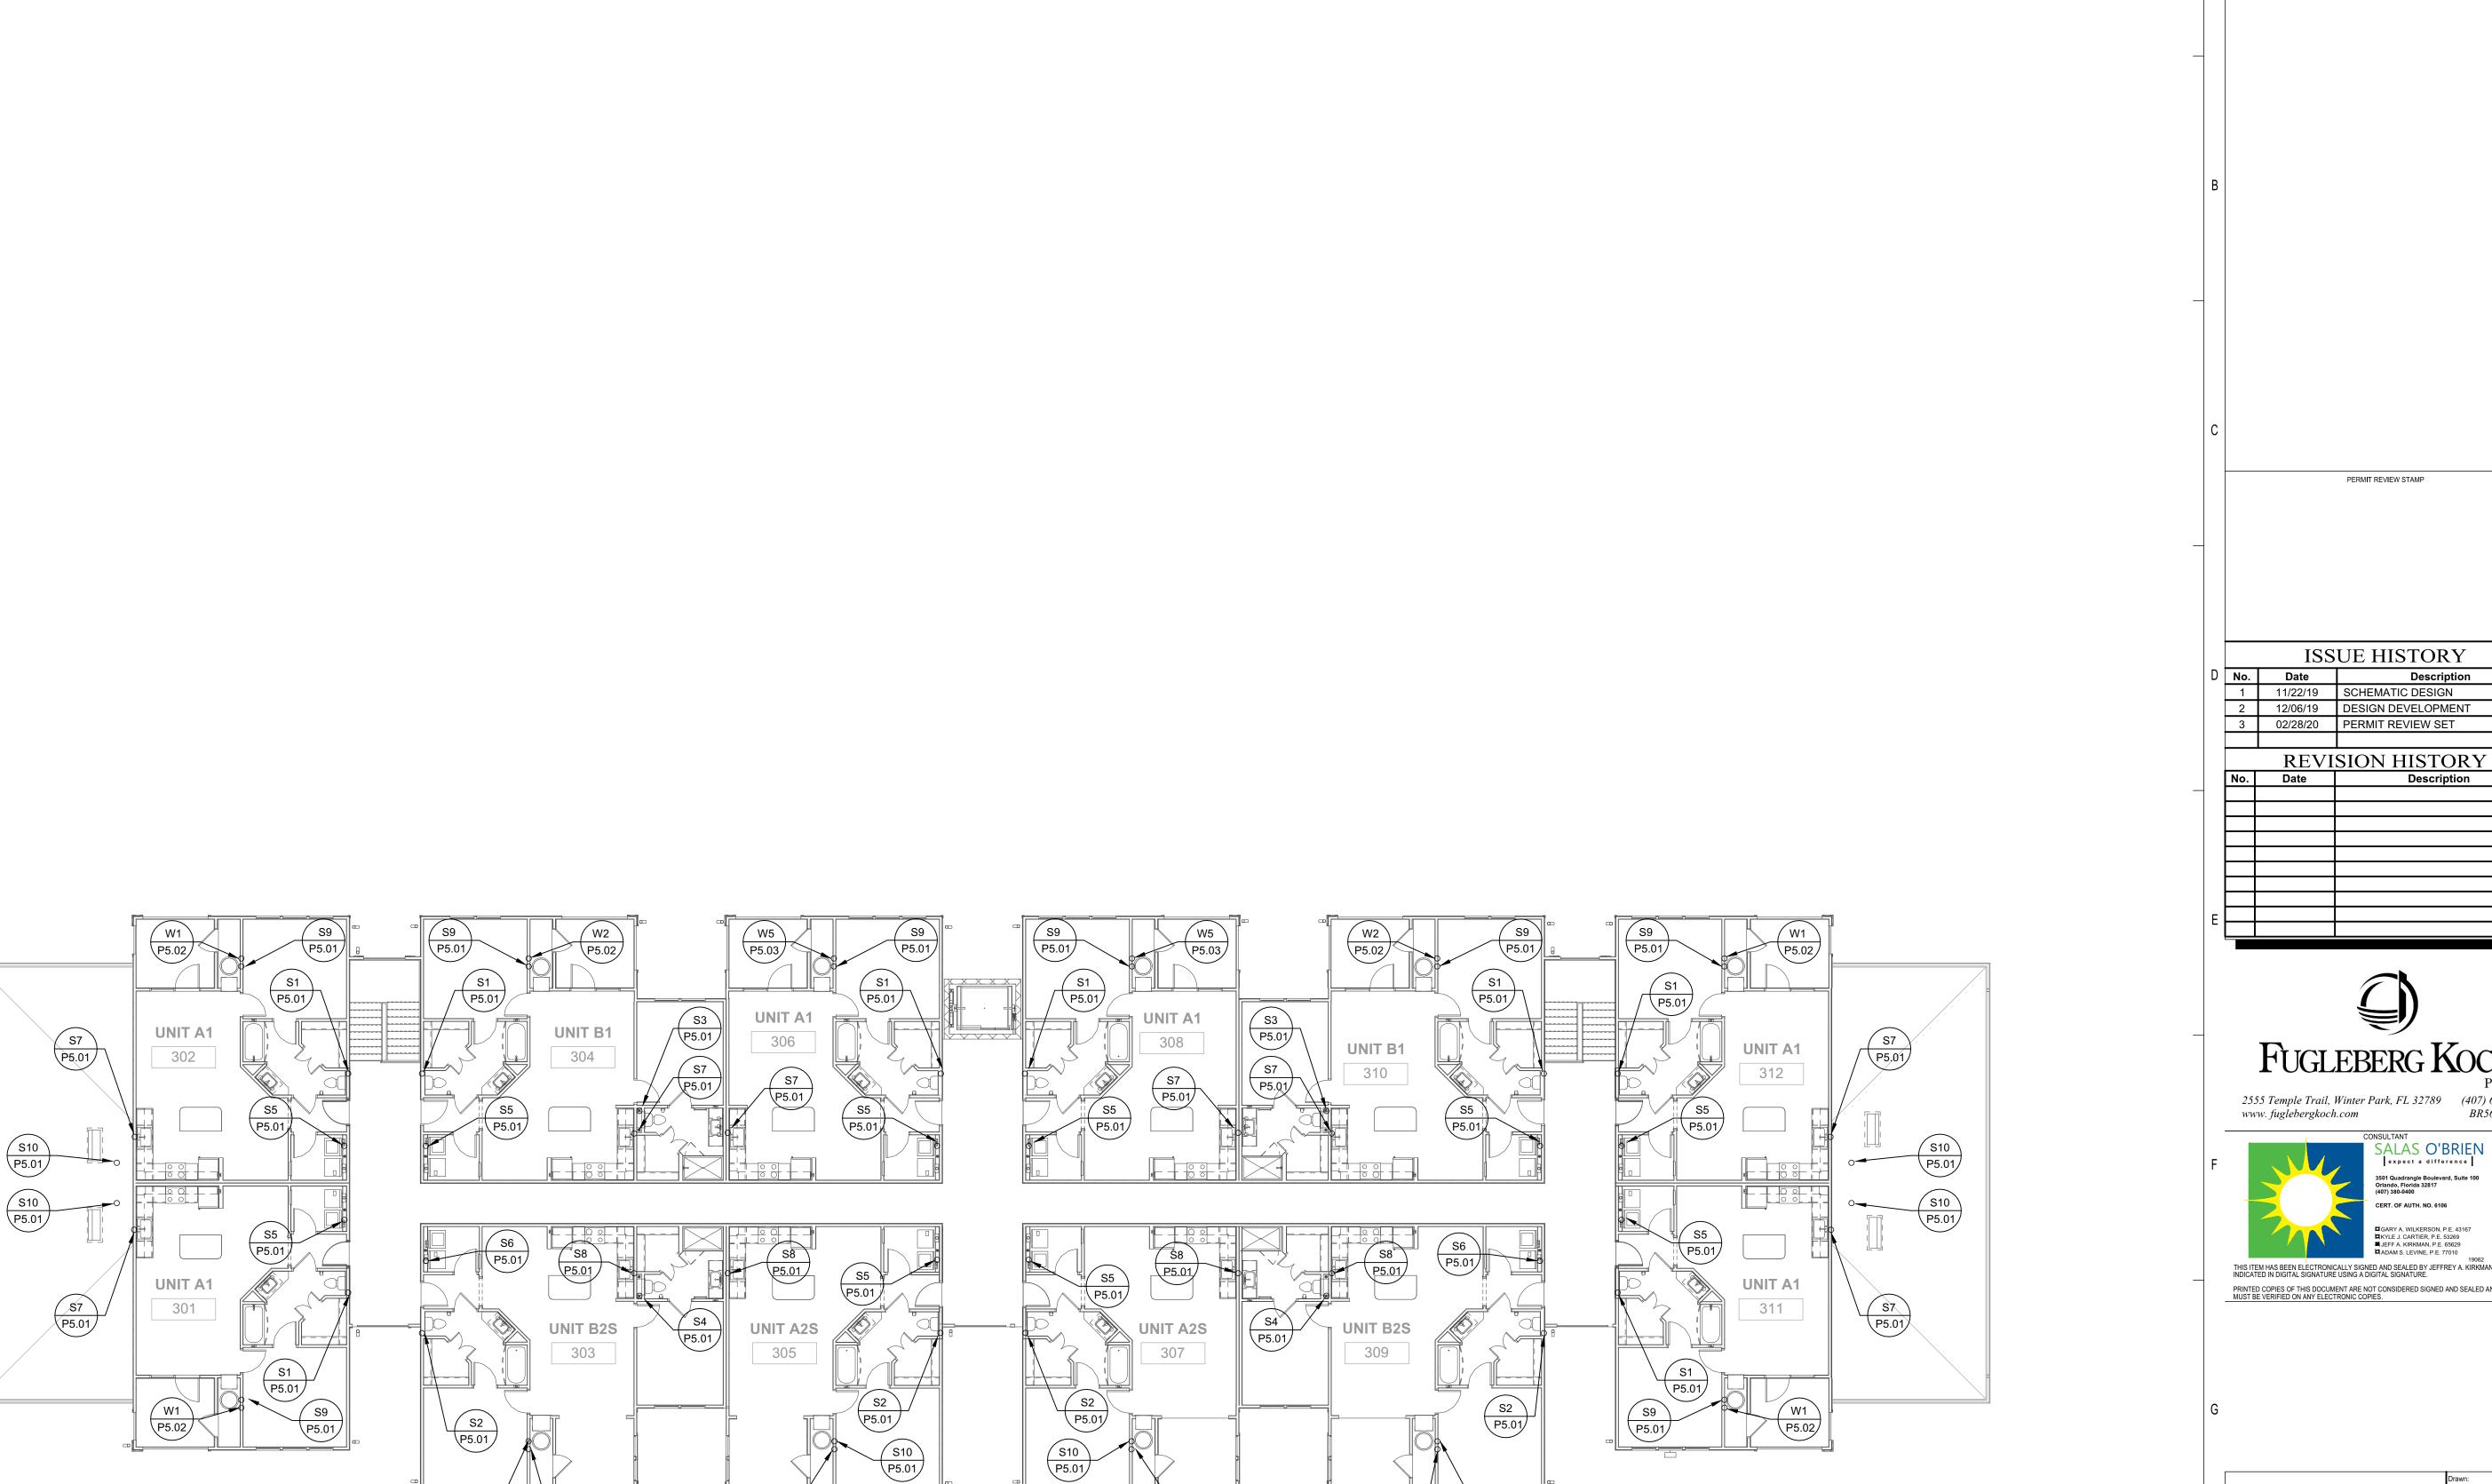

W3 P5.02

S10 P5.01

S10 P5.01

W3 P5.02

W5 P5.03

BUILDING TYPE 3 - 3RD LEVEL - PLUMBING
P2.11 3/32" = 1'-0"

AN New construction of a 3 story apartment building that includes 22 units of 3 types and 6 direct entry garage units. The building provides 30,455 GSF PERMIT REVIEW STAMP **ISSUE HISTORY** Description
 1
 11/22/19
 SCHEMATIC DESIGN

 2
 12/06/19
 DESIGN DEVELOPMENT

CITY OF FORT MYERS

THIS PLAN REVIEWED FOR SUBSTANTIAL CODE COMPLIANCE WITH ALL APPLICABLE CODES.

DATE APPROVED: 06/17/20
PERMIT NUMBER: BLD2020-00851
PROPERTY ADDRESS: 3777 OLD BERRY POINT



Description




THIS ITEM HAS BEEN ELECTRONICALLY SIGNED AND SEALED BY JEFFREY A. KIRKMAN, PE ON DATE INDICATED IN DIGITAL SIGNATURE USING A DIGITAL SIGNATURE. PRINTED COPIES OF THIS DOCUMENT ARE NOT CONSIDERED SIGNED AND SEALED AND THE SIGNATURE MUST BE VERIFIED ON ANY ELECTRONIC COPIES.

THE ROBERT


FT. MYERS, FL

BUILDING TYPE 3 - 3RD LEVEL - PLUMBING


P2.11

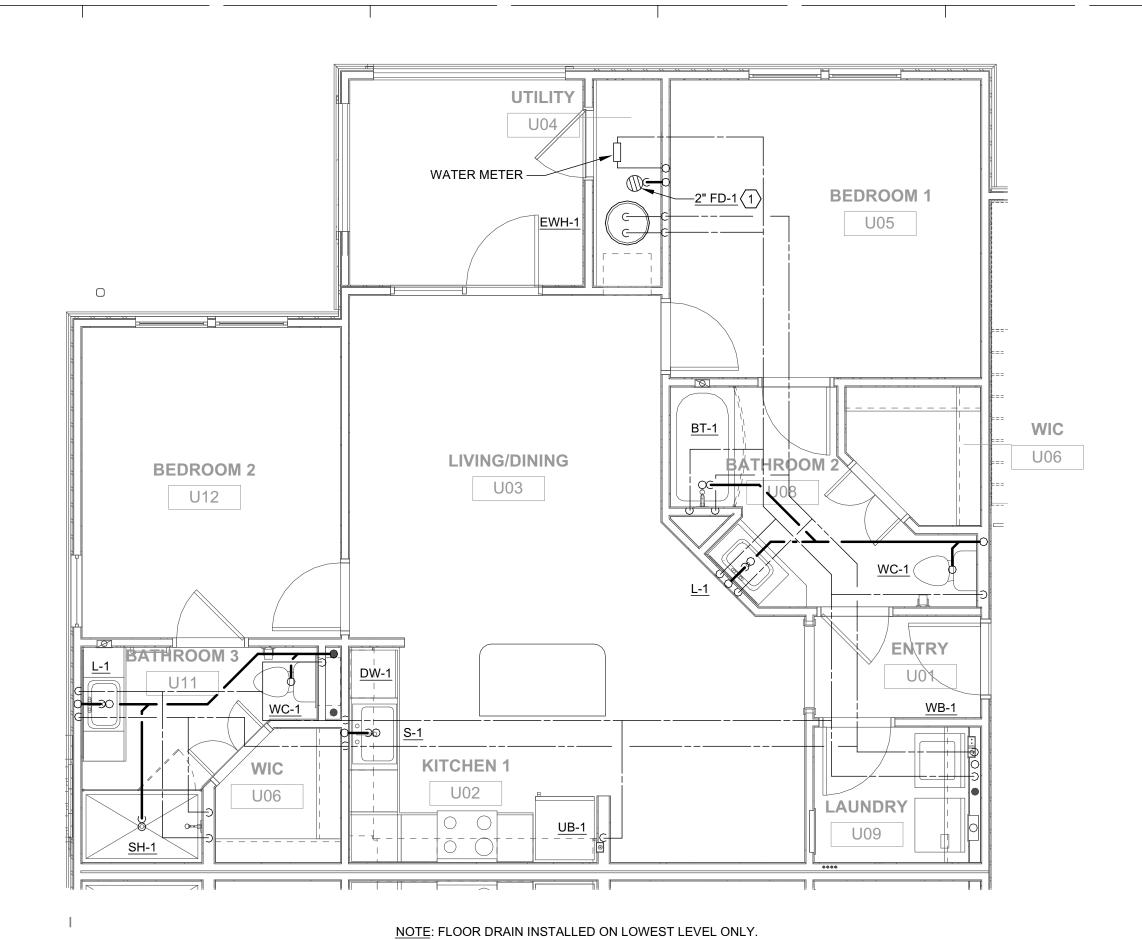

UNIT B1 FLOOR PLAN - PLUMBING

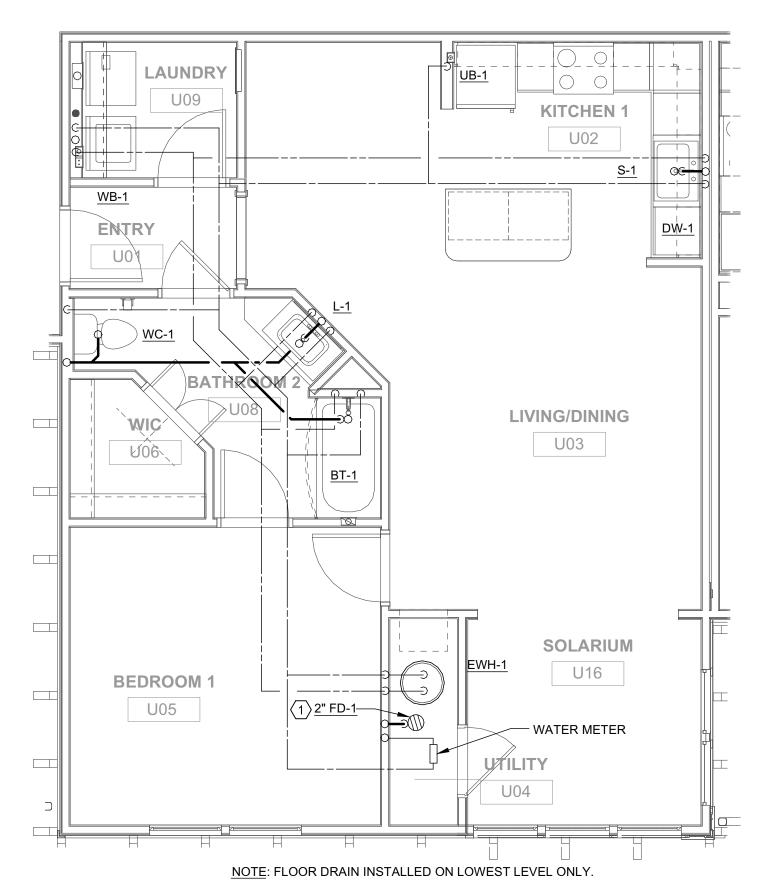




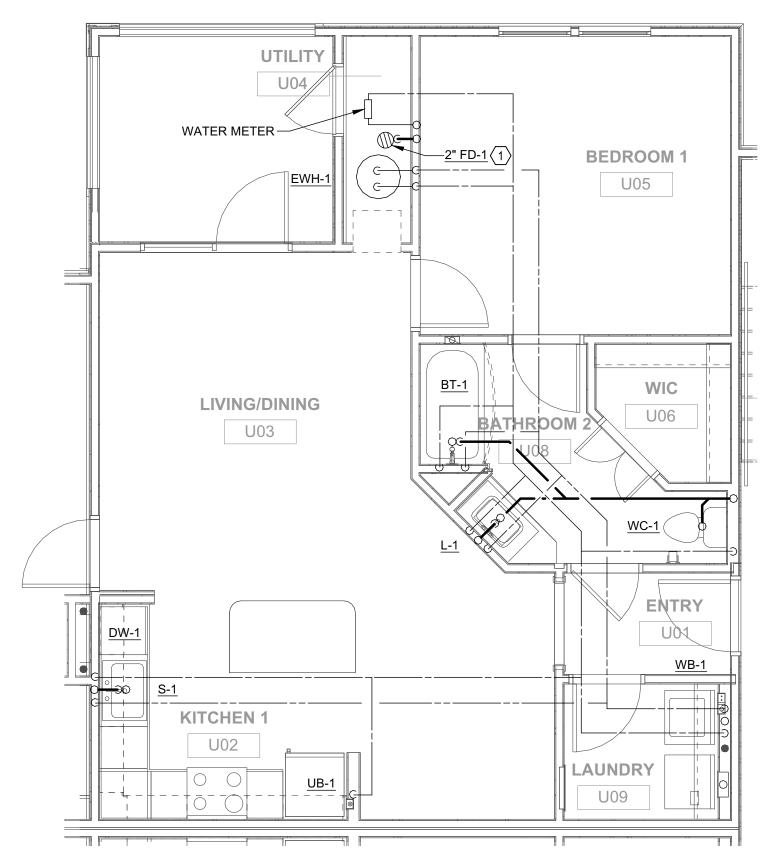


NOTE: FLOOR DRAIN INSTALLED ON LOWEST LEVEL ONLY.



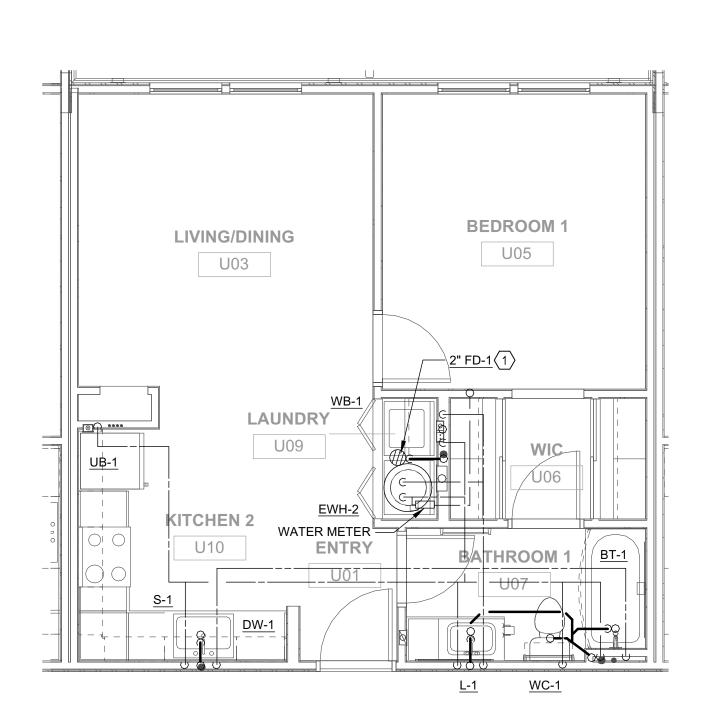

NOTE: FLOOR DRAIN INSTALLED ON LOWEST LEVEL ONLY.



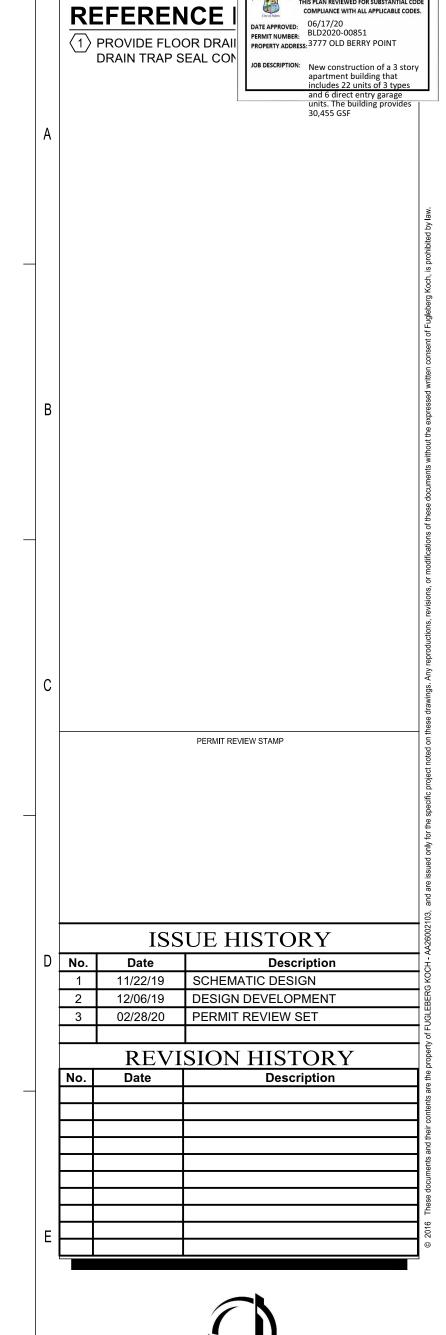




THIS ITEM HAS BEEN ELECTRONICALLY SIGNED AND SEALED BY JEFFREY A. KIRKMAN, PE ON DATE INDICATED IN DIGITAL SIGNATURE USING A DIGITAL SIGNATURE.

PRINTED COPIES OF THIS DOCUMENT ARE NOT CONSIDERED SIGNED AND SEALED AND THE SIGNATURE MUST BE VERIFIED ON ANY ELECTRONIC COPIES.


	Drawn:	SWC
THE DODEDT	Checked:	RDP
THE ROBERT	Approval:	JAK
	Date:	09/10/2019
FT. MYERS, FL	Project #:	5592
	_	

UNIT PLANS - PLUMBING


P3.01

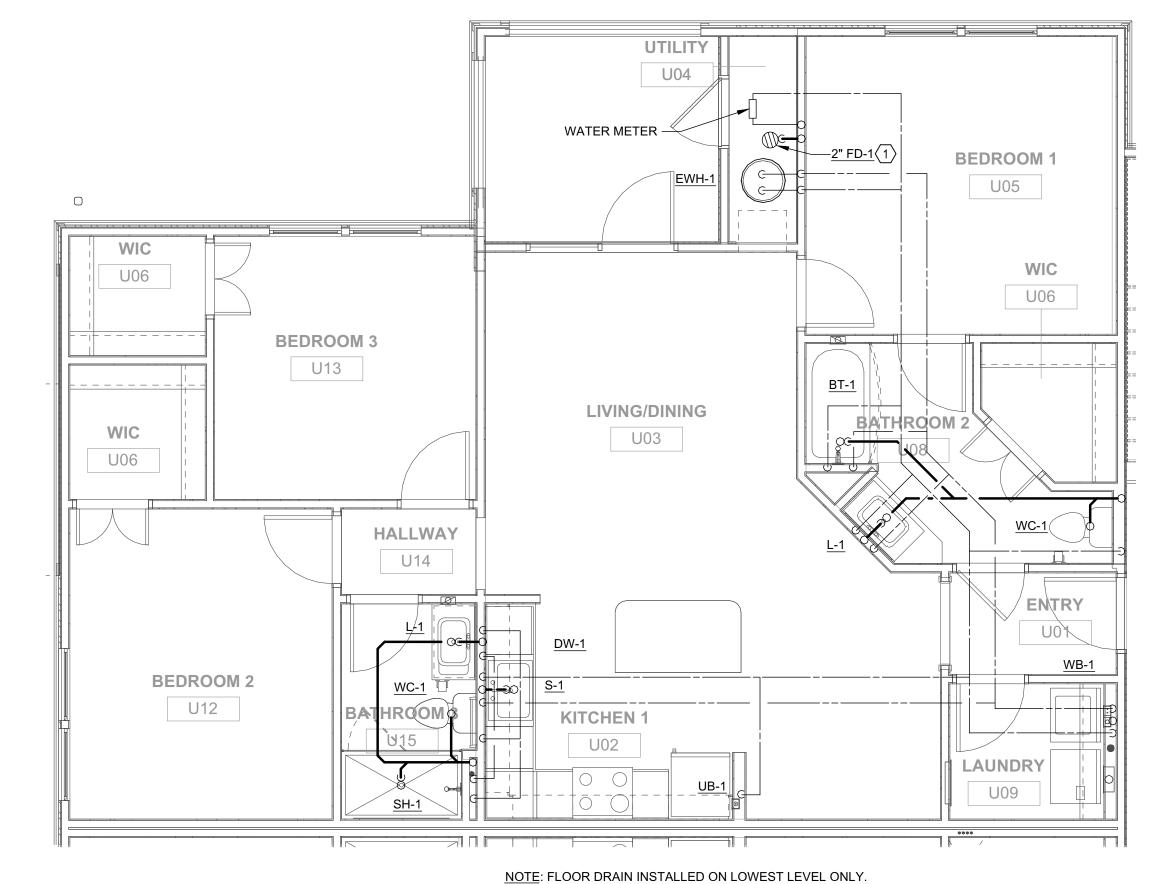

UNIT C1 FLOOR PLAN - PLUMBING P3.02 1/4" = 1'-0"

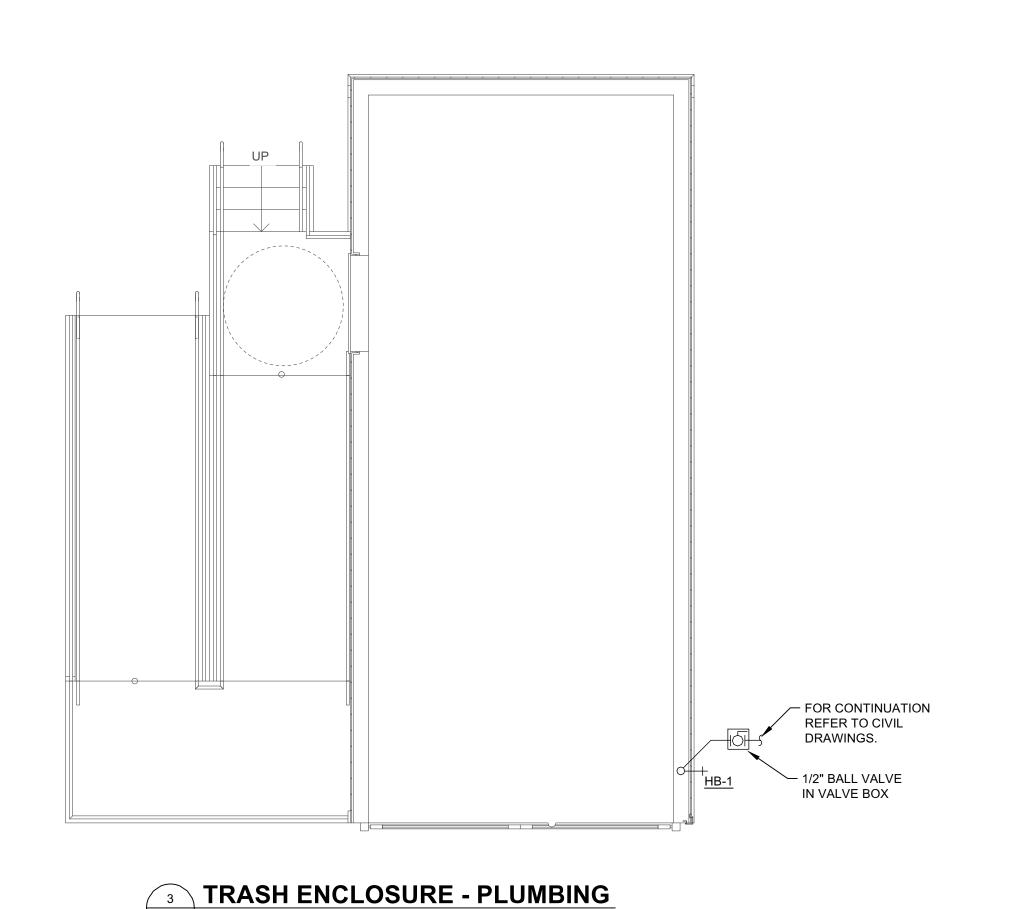

P3.02 1/4"=1'-0"

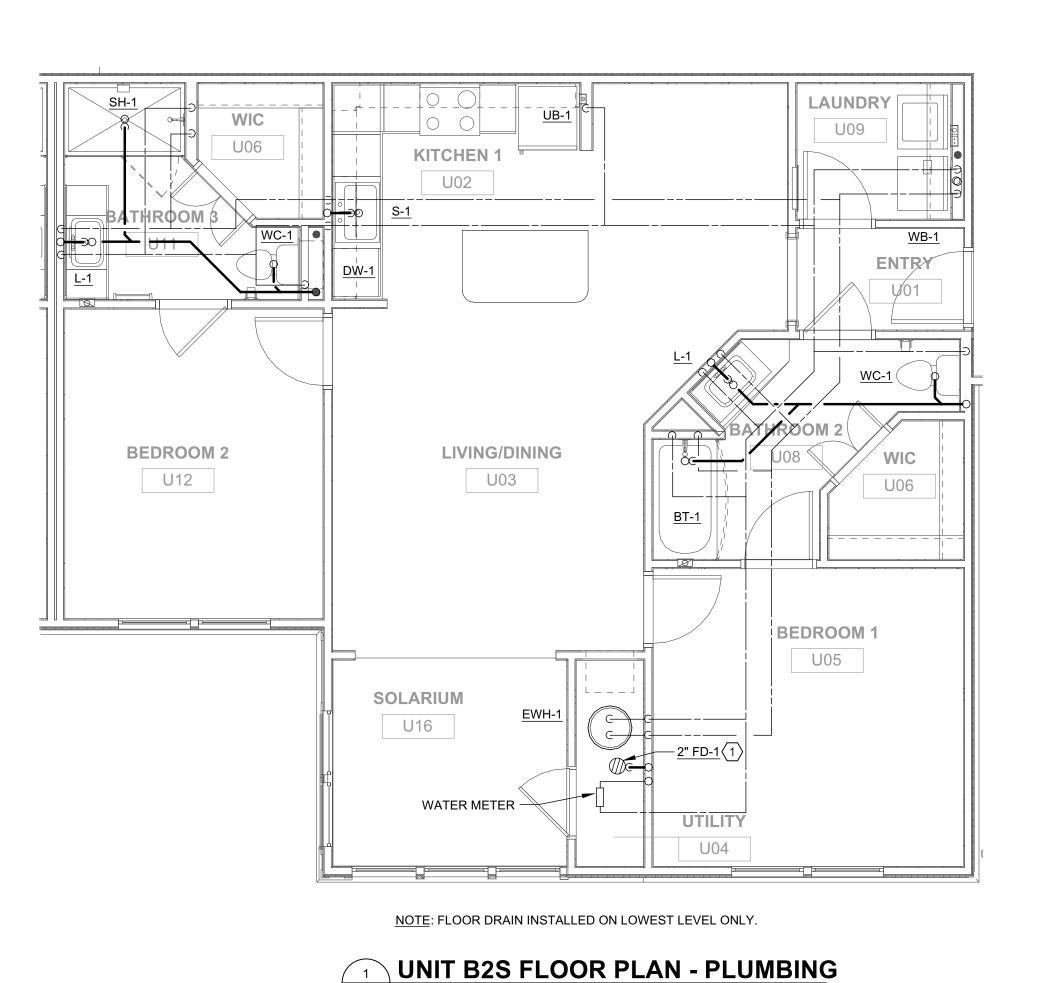

P3.02 1/4" = 1'-0"

THIS ITEM HAS BEEN ELECTRONICALLY SIGNED AND SEALED BY JEFFREY A. KIRKMAN, PE ON DATE INDICATED IN DIGITAL SIGNATURE USING A DIGITAL SIGNATURE. PRINTED COPIES OF THIS DOCUMENT ARE NOT CONSIDERED SIGNED AND SEALED AND THE SIGNATURE MUST BE VERIFIED ON ANY ELECTRONIC COPIES. THE ROBERT 09/10/2019 5592 FT. MYERS, FL UNIT PLANS AND TRASH **ENCLOSURE - PLUMBING** P3.02

REFERENCE |

DATE APPROVED: 06/17/20
PERMIT NUMBER: BLD2020-00851
PROVIDE FLOOR DRAII
DRAIN TRAP SEAL CON

DATE APPROVED: 06/17/20
PERMIT NUMBER: BLD2020-00851
PROPERTY ADDRESS: 3777 OLD BERRY POINT
JOB DESCRIPTION.

PERMIT REVIEW STAMP

ISSUE HISTORY

REVISION HISTORY

FUGLEBERG KOCH

2555 Temple Trail, Winter Park, FL 32789 (407) 629-0595 www.fuglebergkoch.com BR569

PERMIT REVIEW SET

1 11/22/19 SCHEMATIC DESIGN
2 12/06/19 DESIGN DEVELOPMENT


Description


Description


No. Date

02/28/20

Date

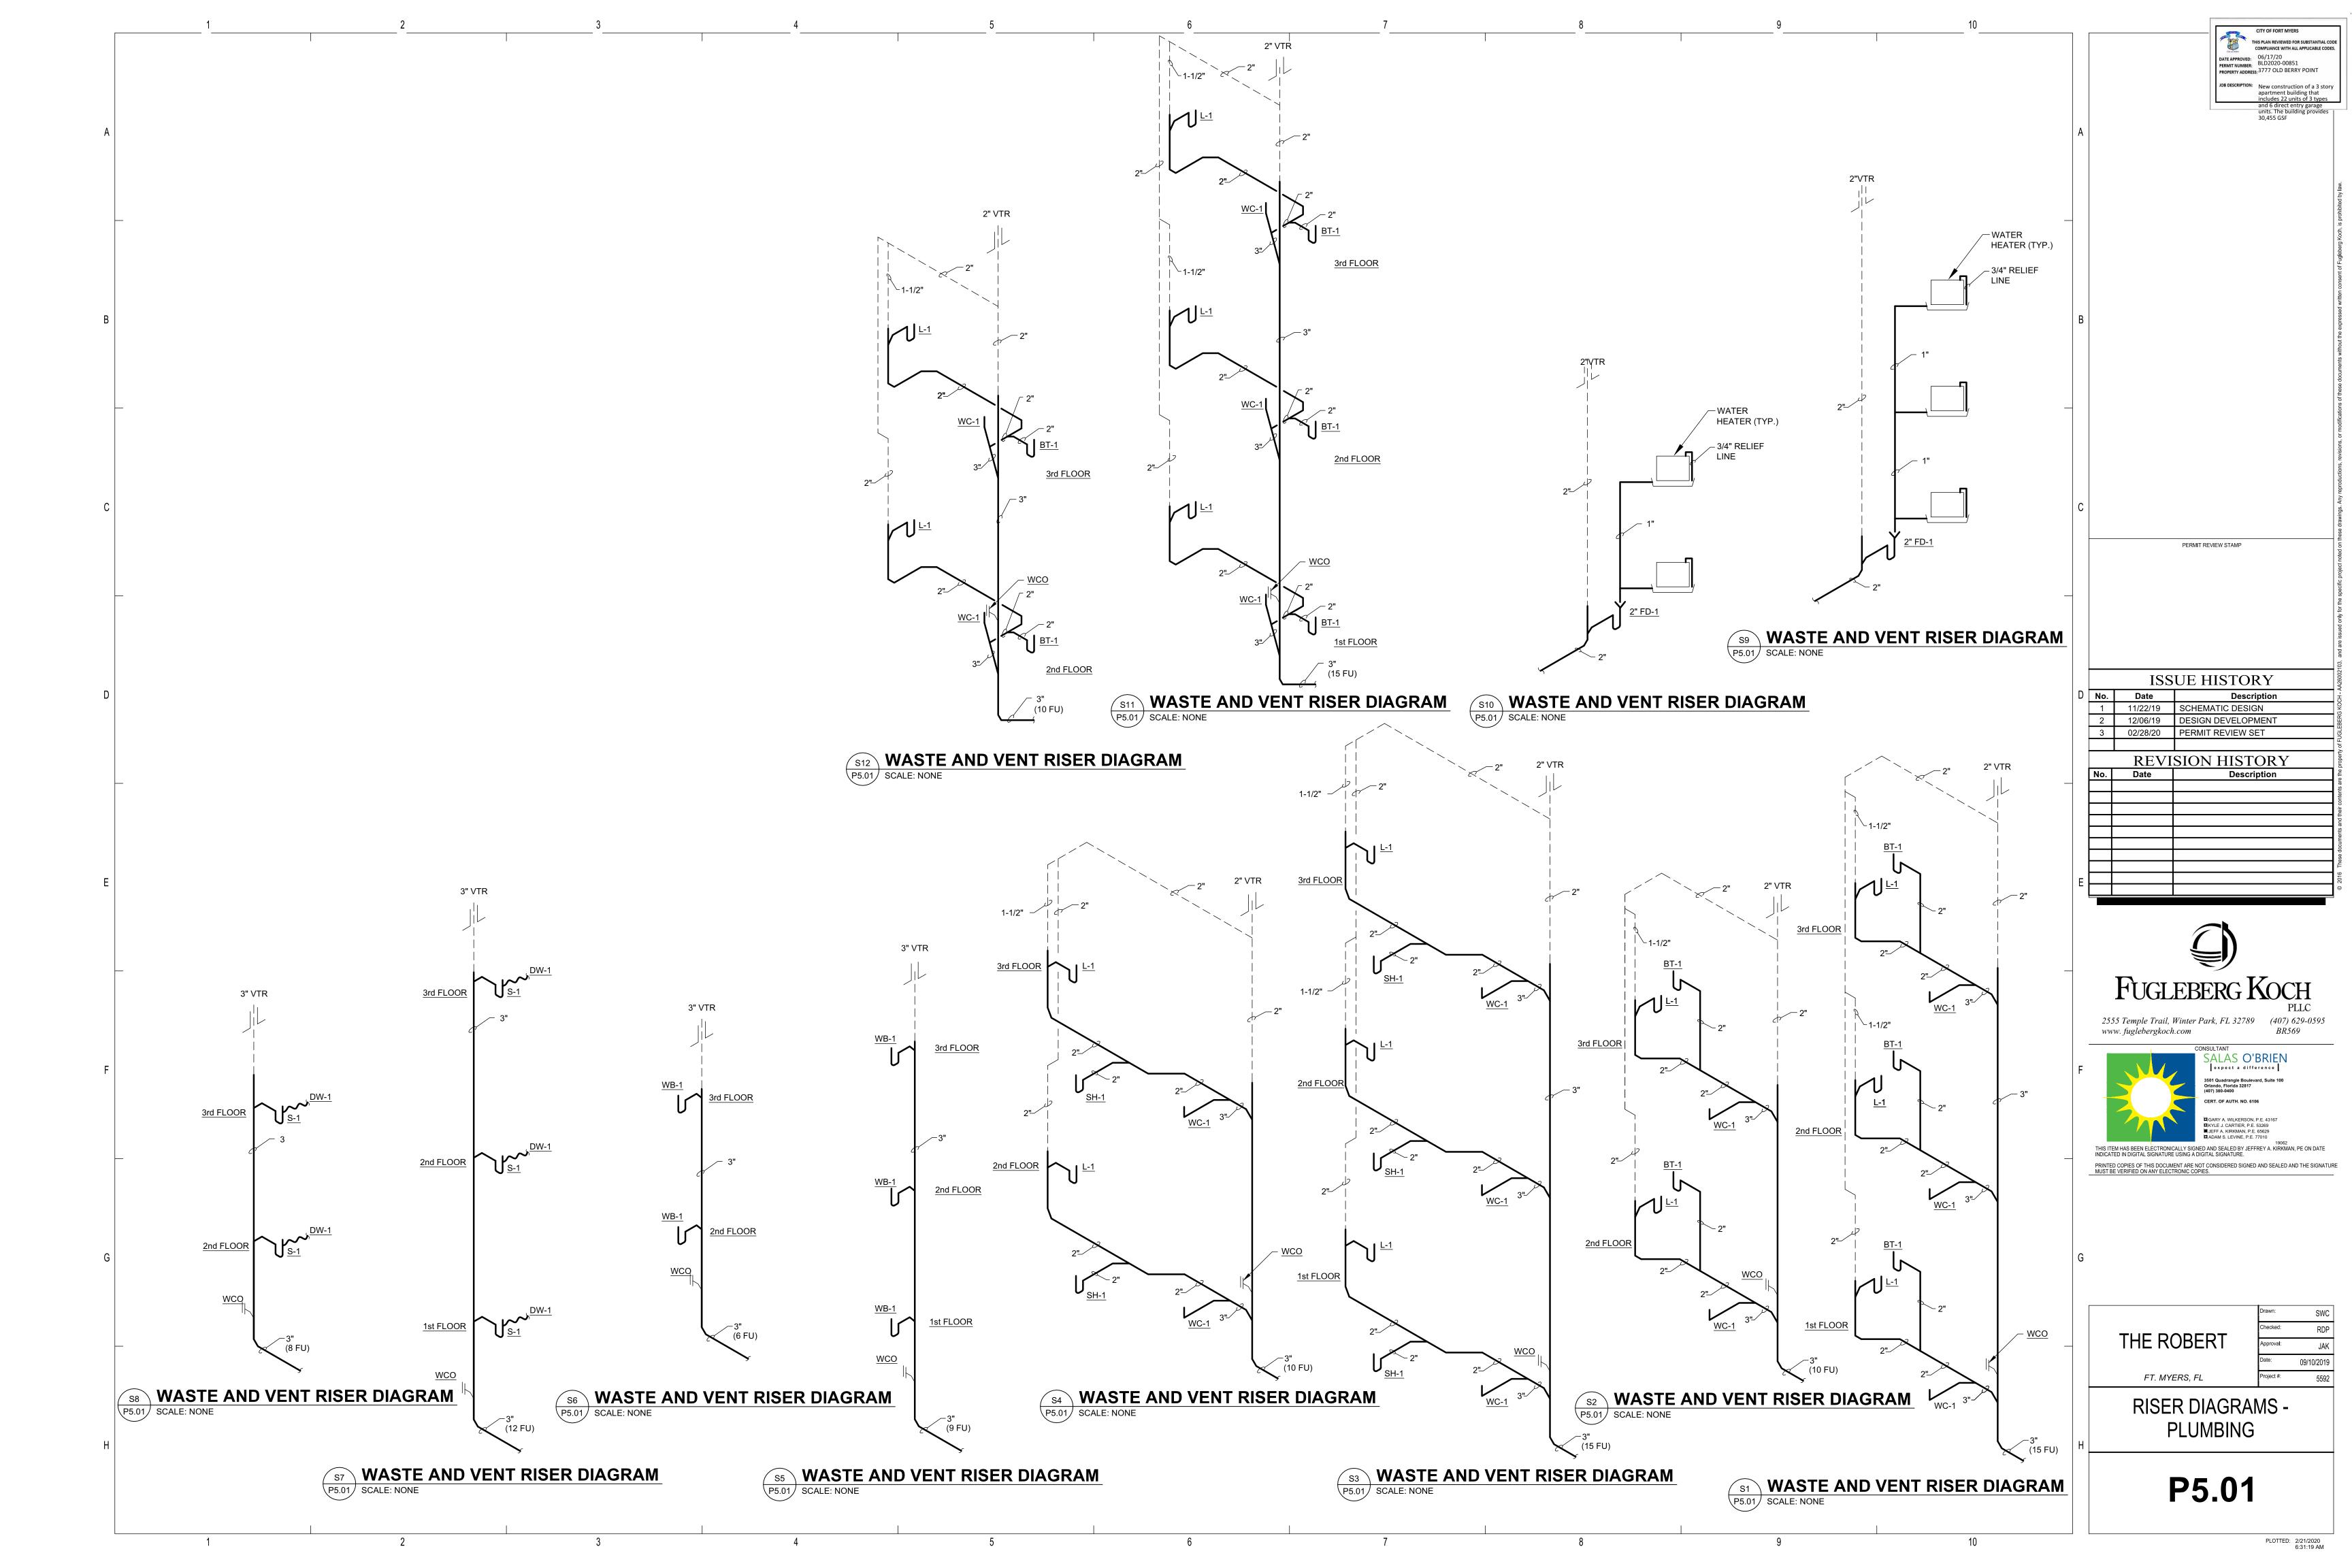

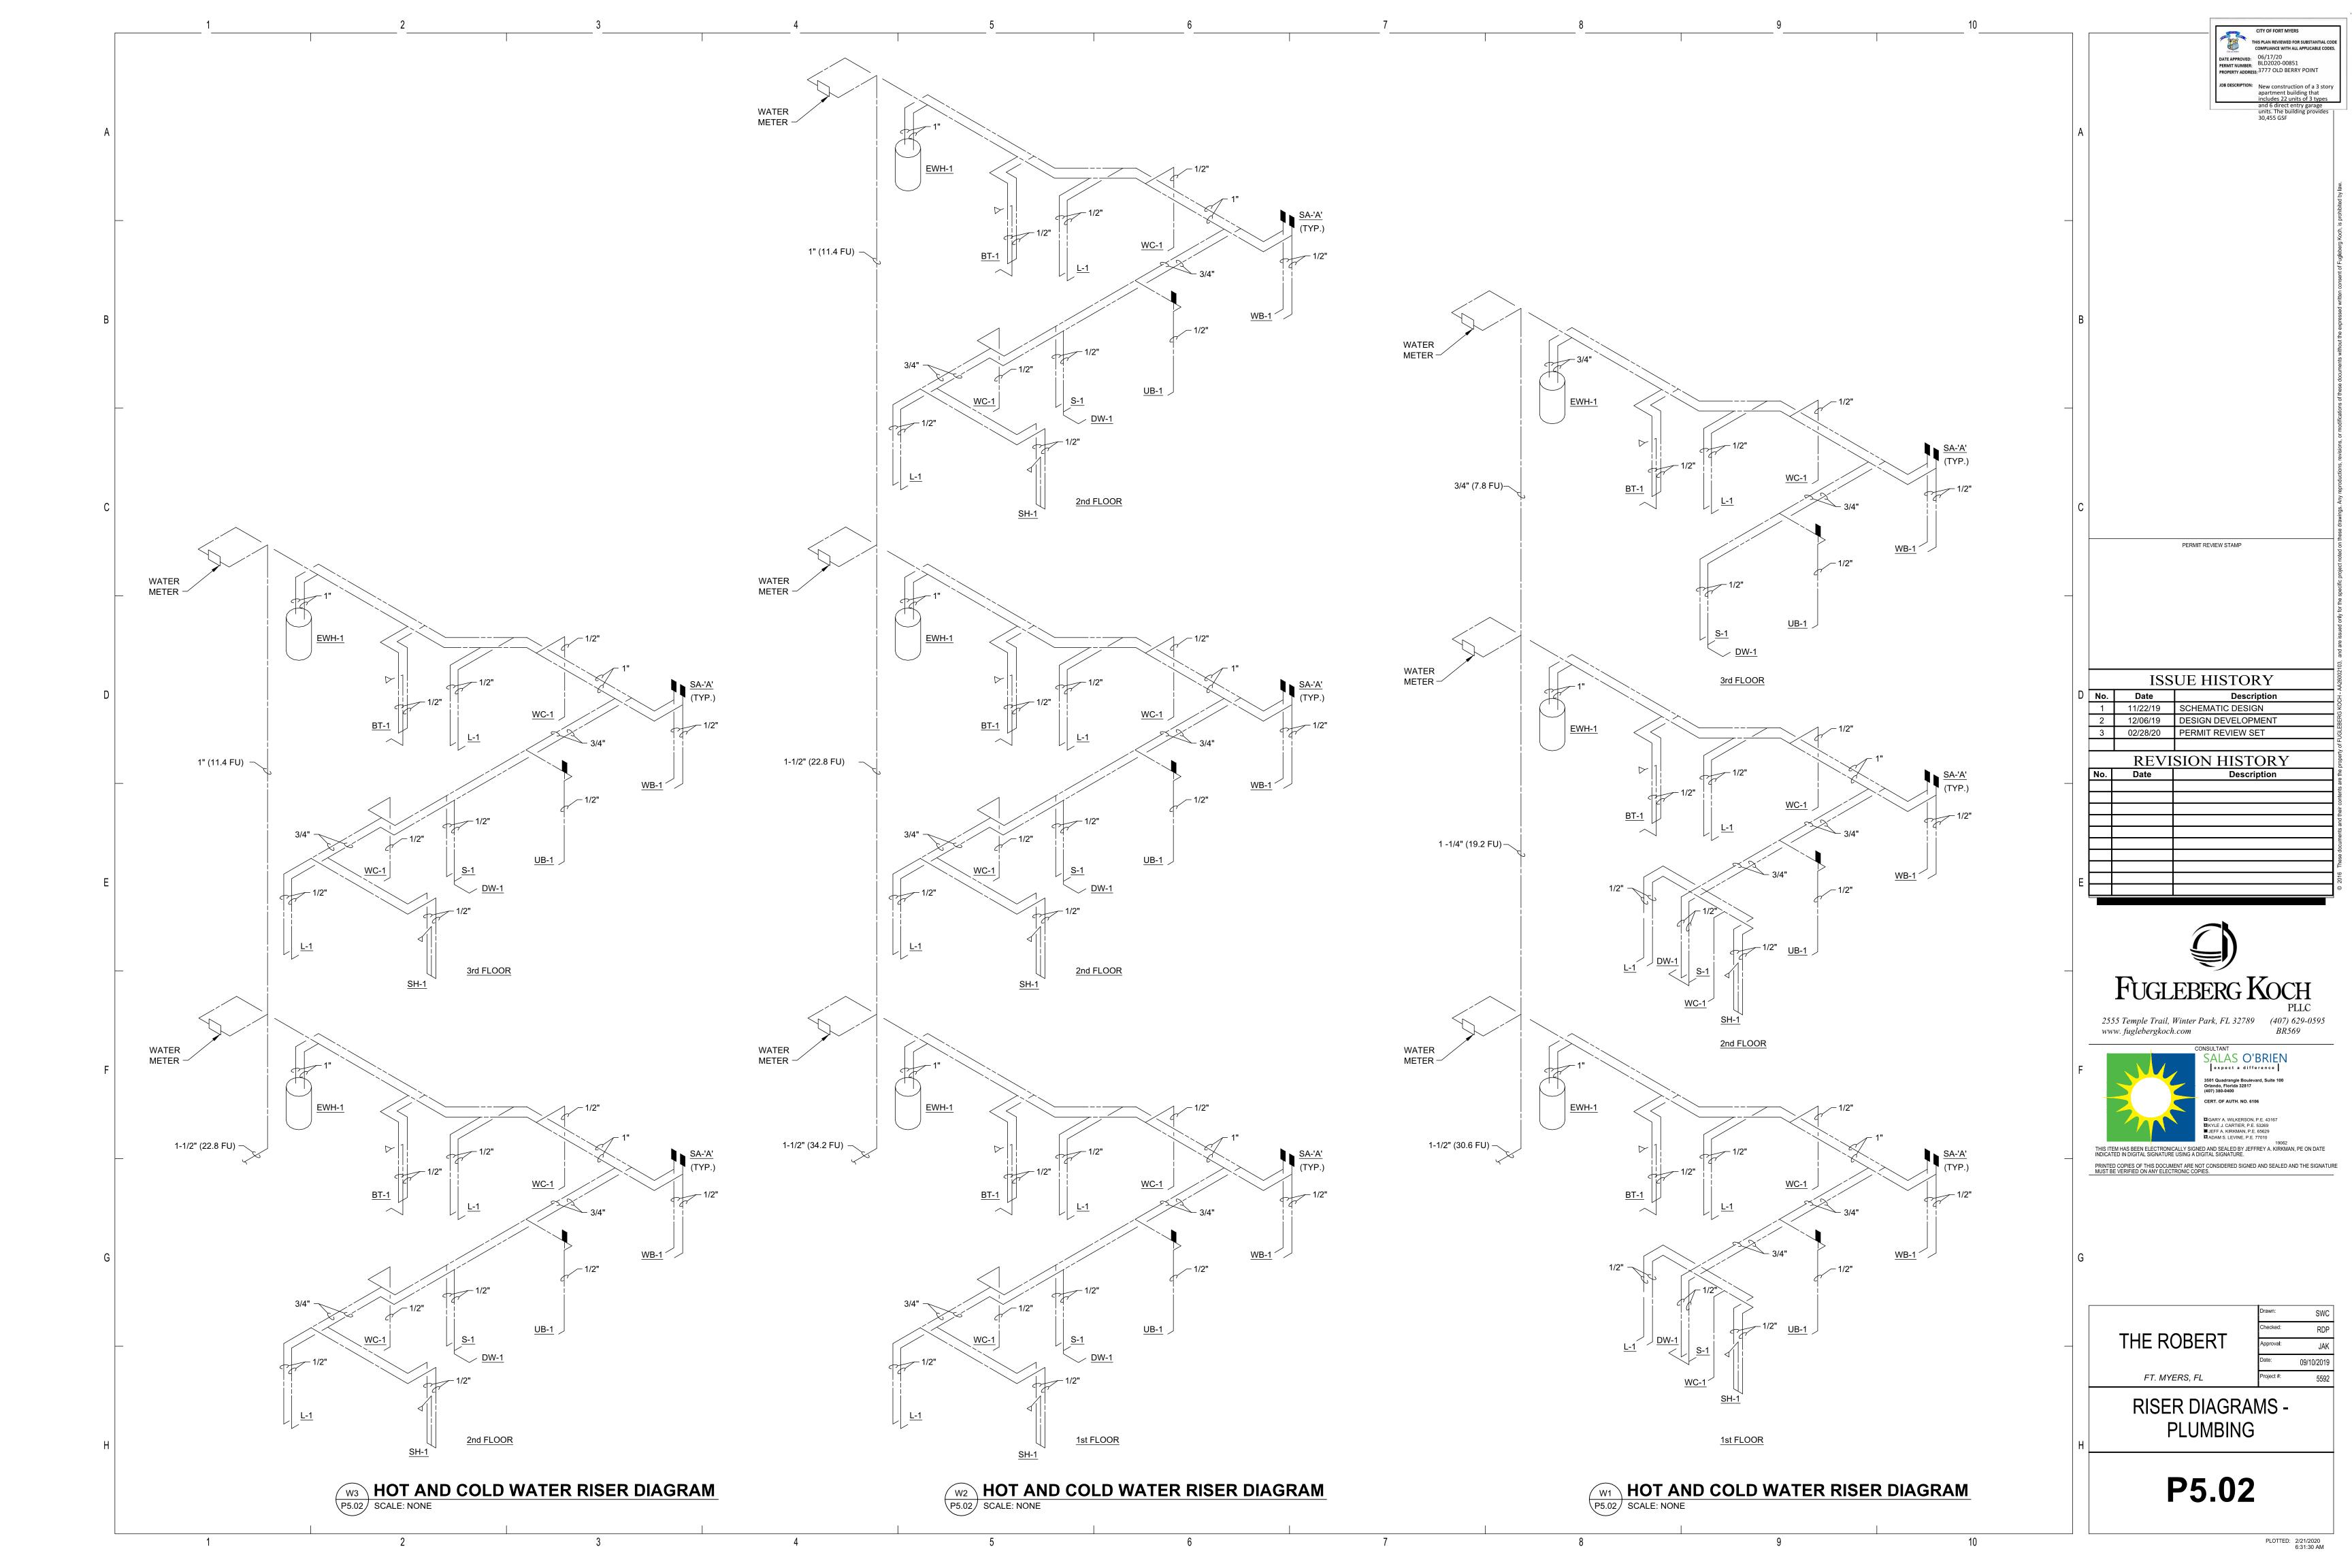

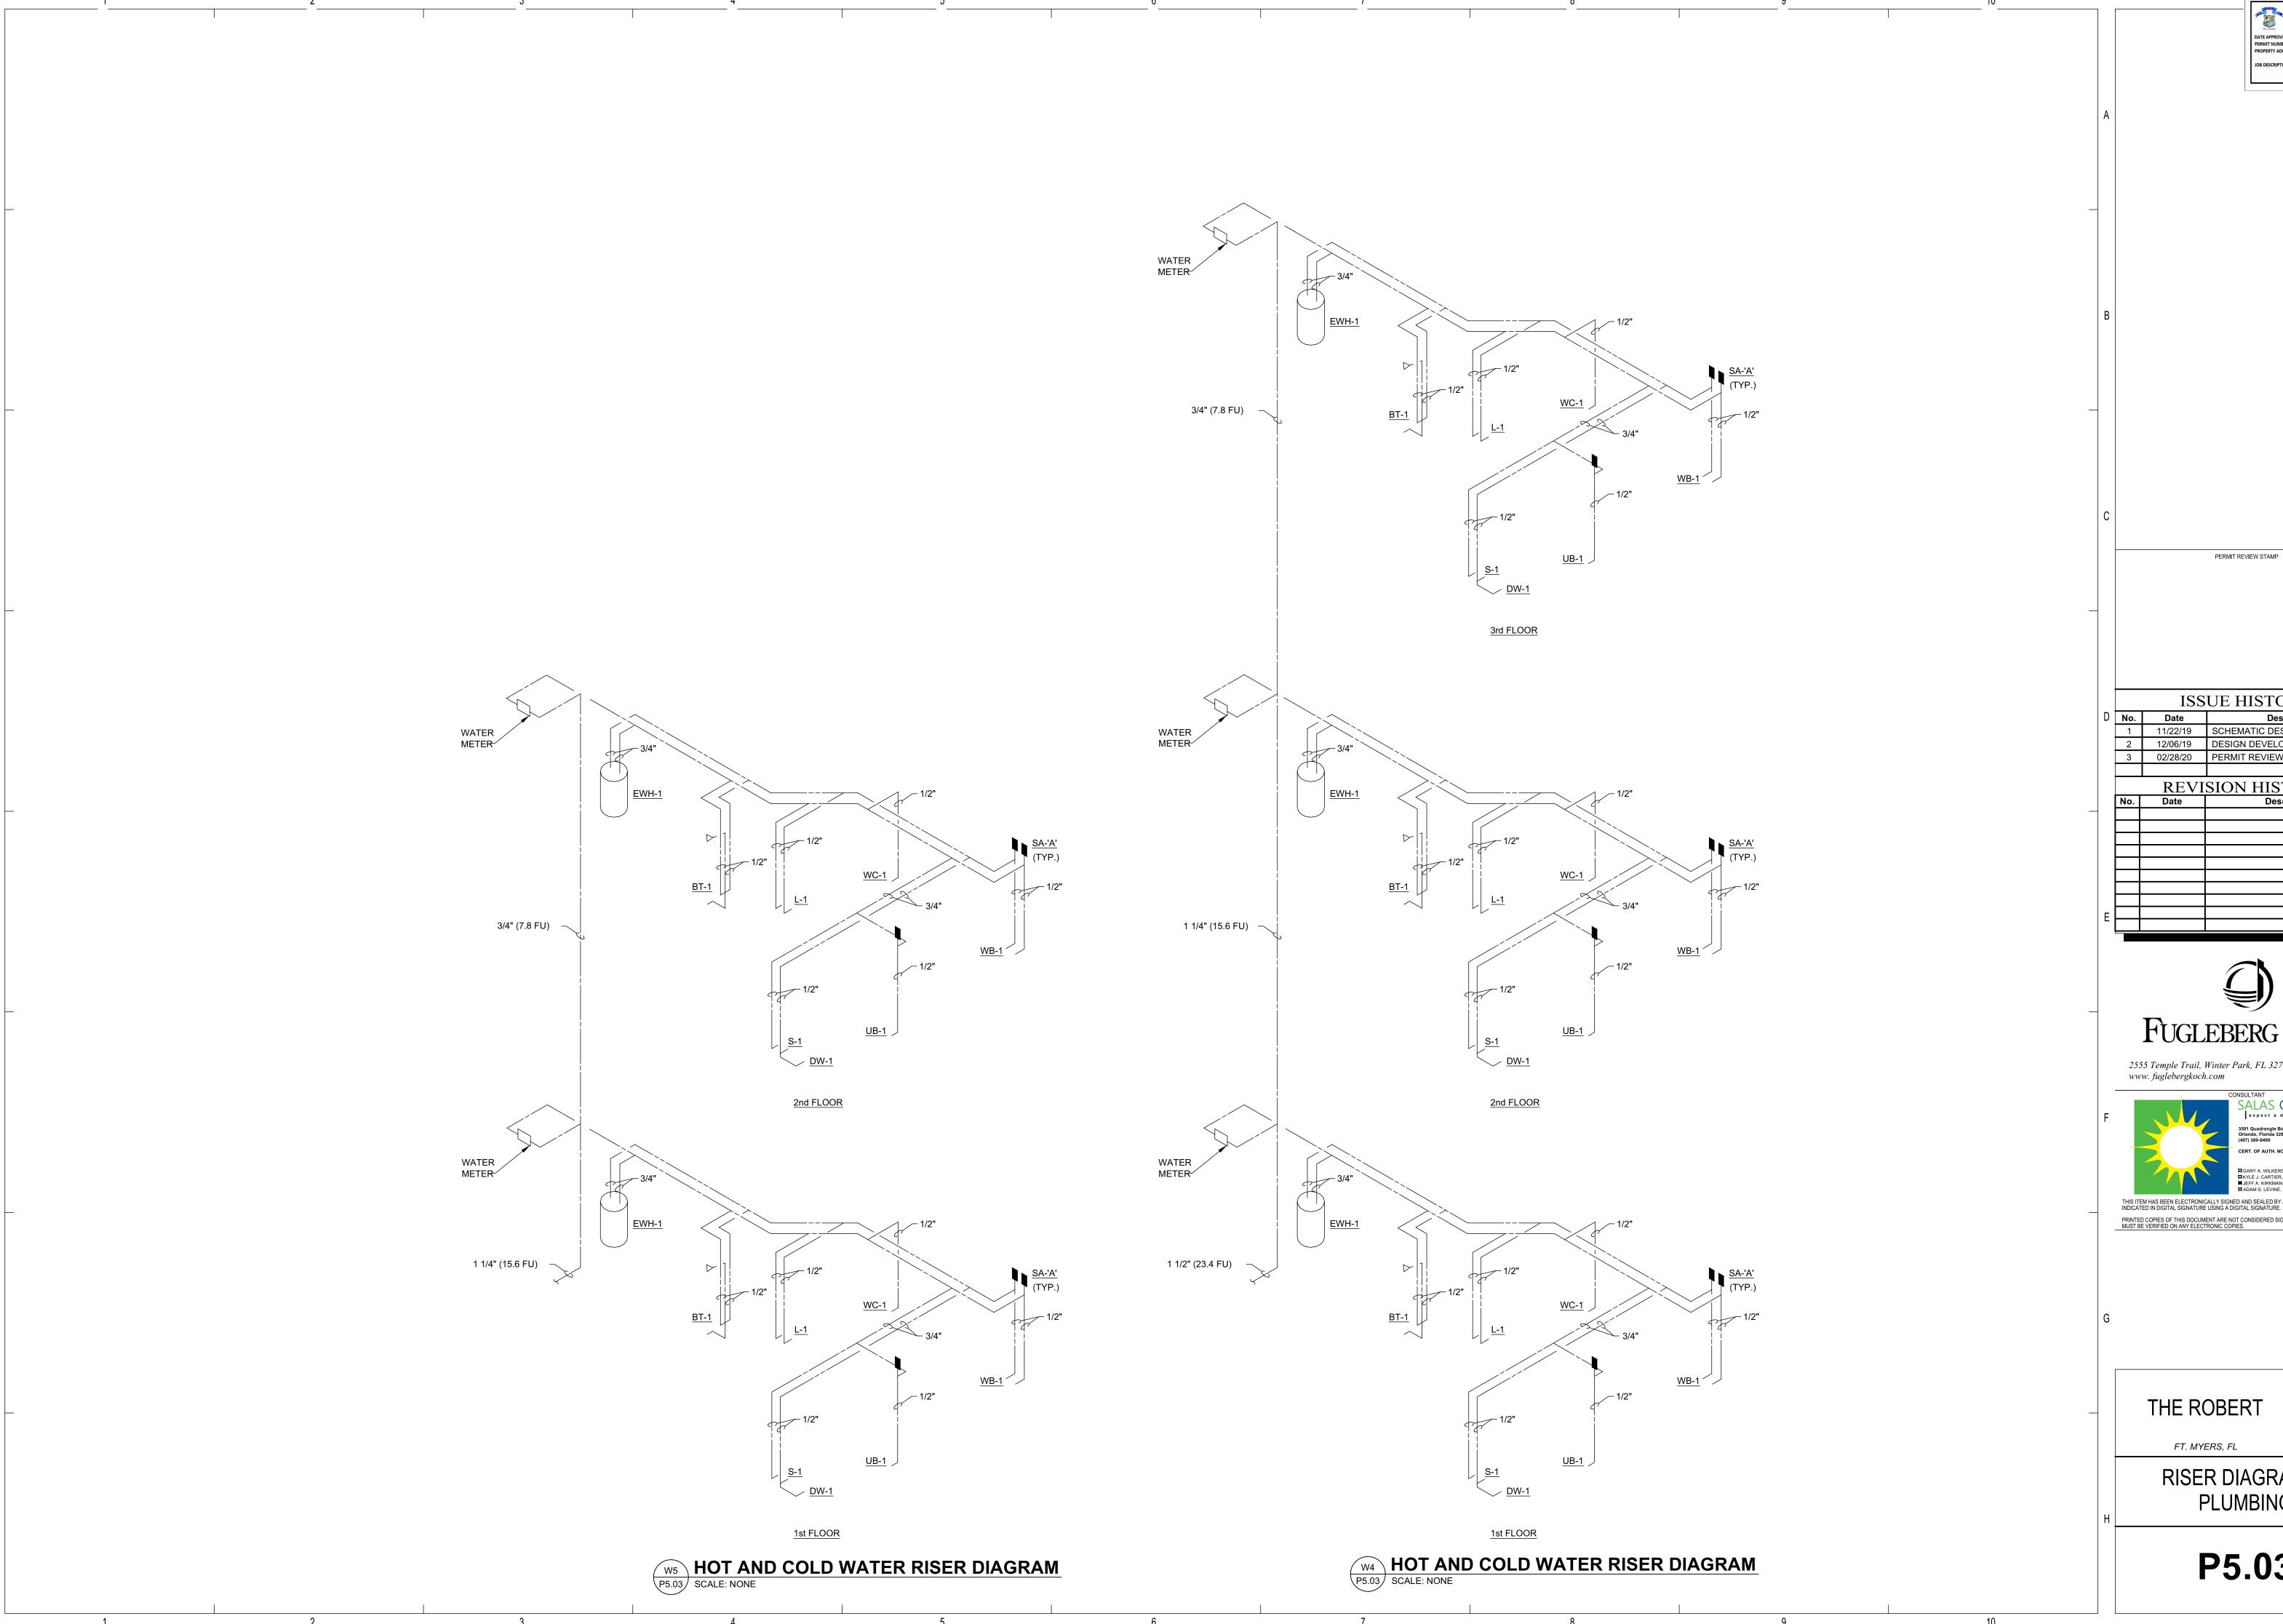

DATE APPROVED: 06/17/20
PERMIT NUMBER: BLD2020-00851
PROPERTY ADDRESS: 3777 OLD BERRY POINT

ISSUE HISTORY Description 1 11/22/19 SCHEMATIC DESIGN
2 12/06/19 DESIGN DEVELOPMENT PERMIT REVIEW SET REVISION HISTORY Description







19962 THIS ITEM HAS BEEN ELECTRONICALLY SIGNED AND SEALED BY JEFFREY A. KIRKMAN, PE ON DATE INDICATED IN DIGITAL SIGNATURE USING A DIGITAL SIGNATURE. PRINTED COPIES OF THIS DOCUMENT ARE NOT CONSIDERED SIGNED AND SEALED AND THE SIGNATURE MUST BE VERIFIED ON ANY ELECTRONIC COPIES.


> THE ROBERT 09/10/2019 5592

RISER DIAGRAMS -**PLUMBING**

P5.03

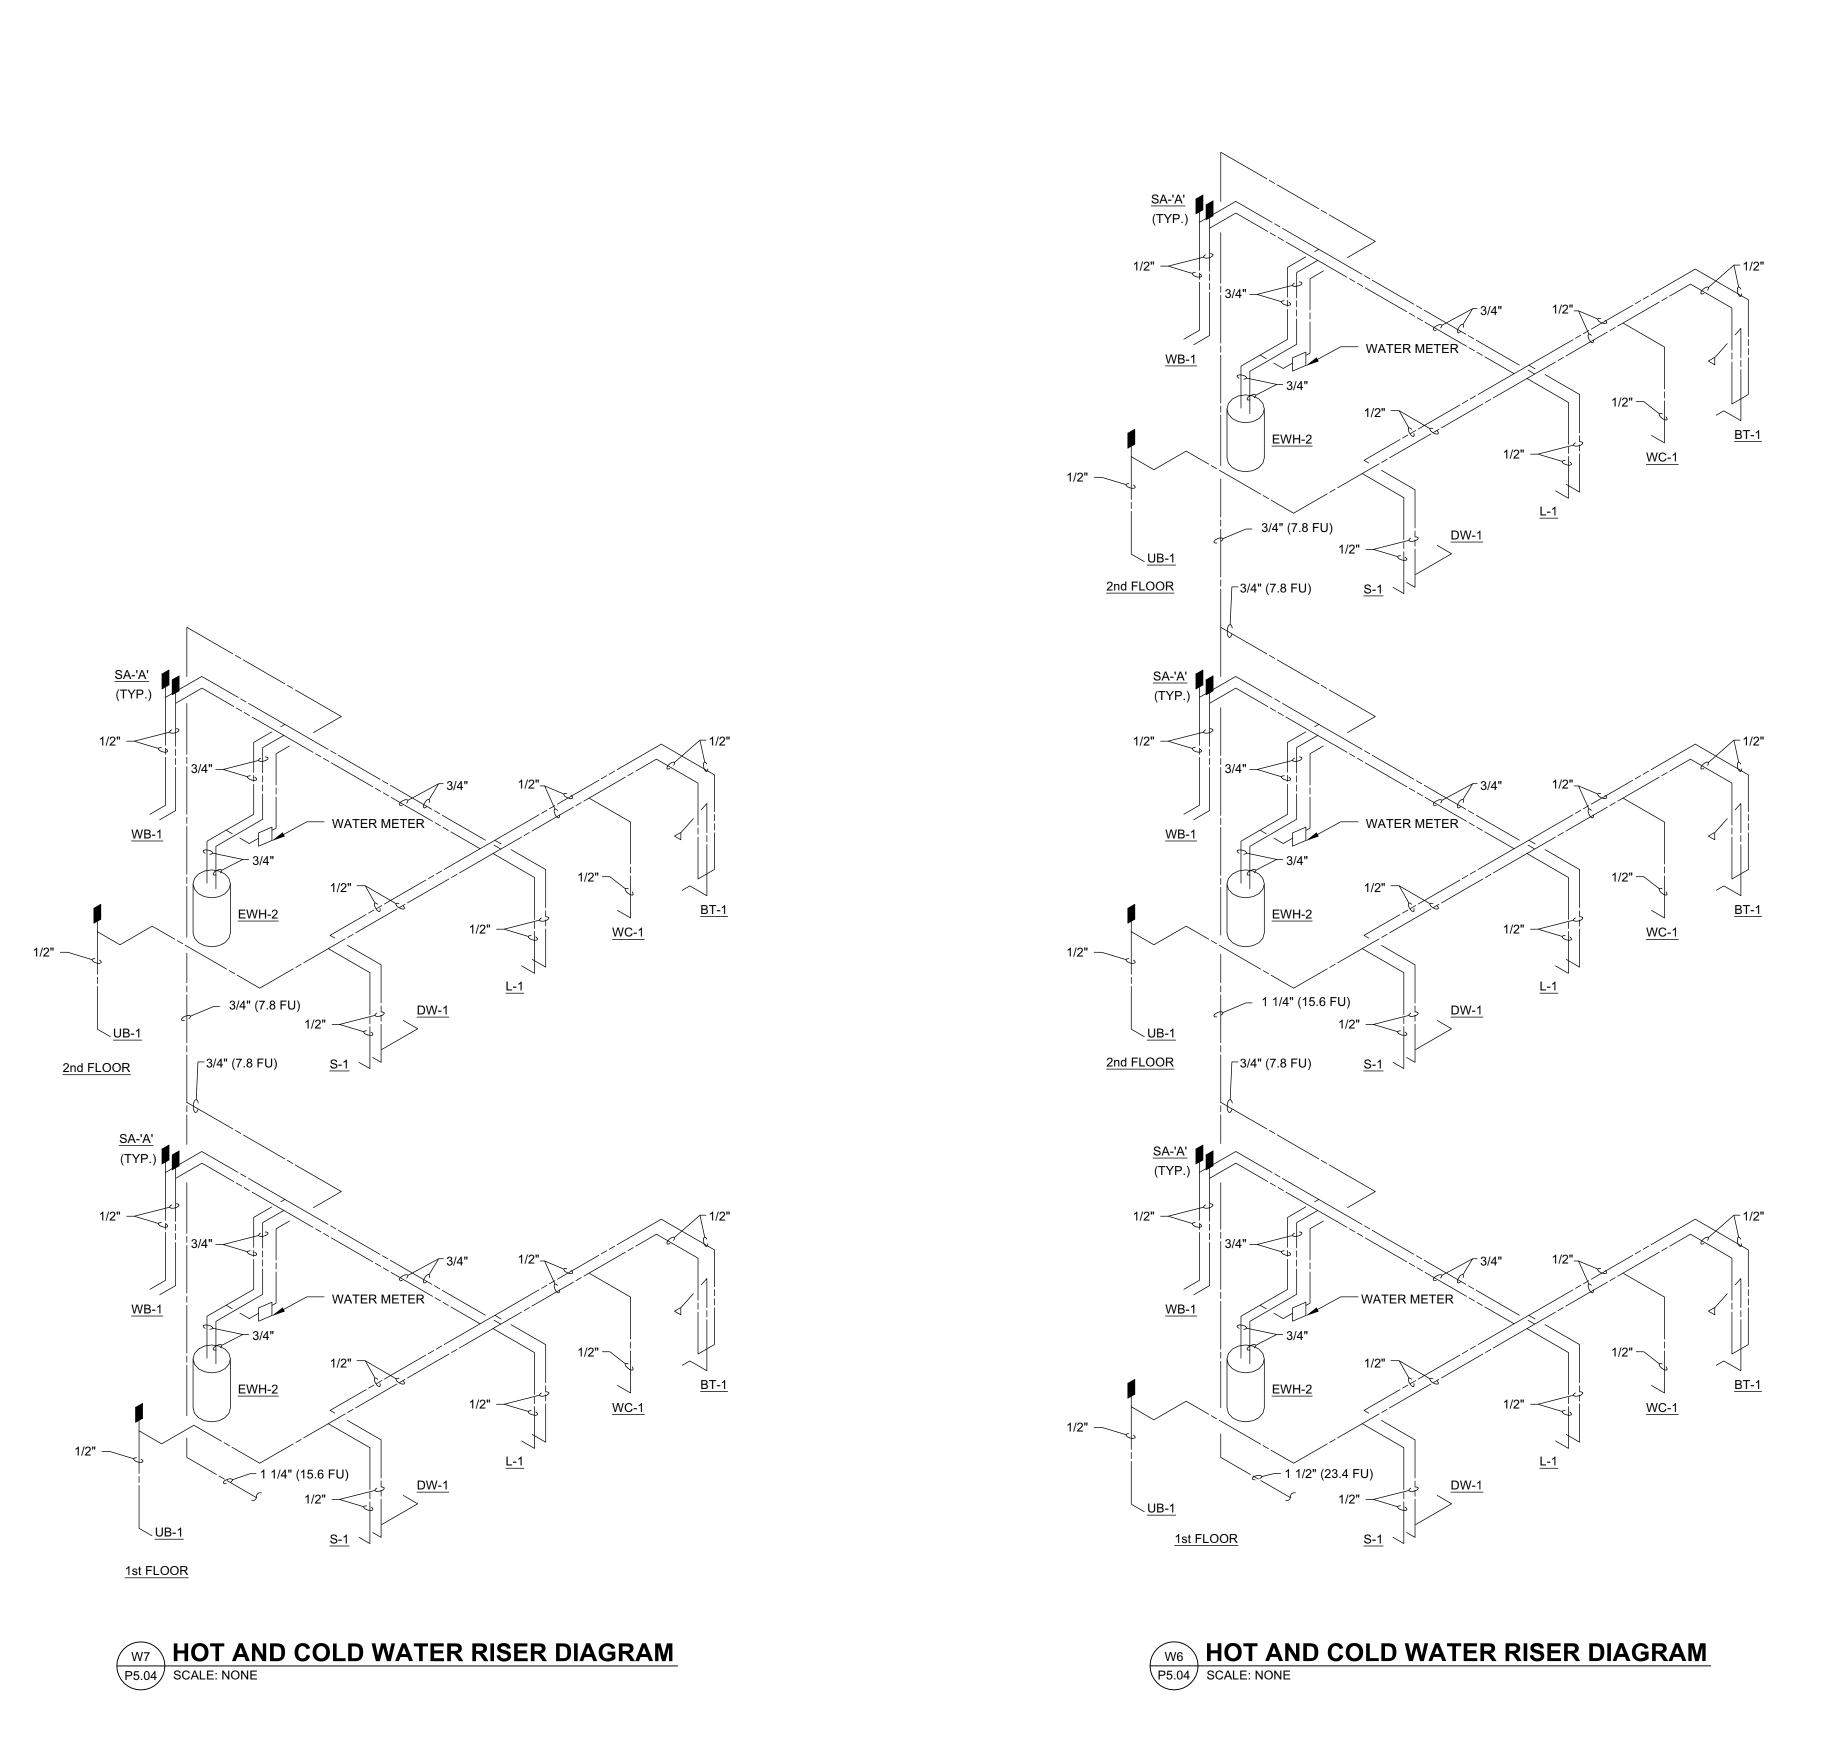

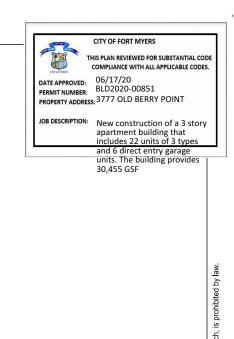

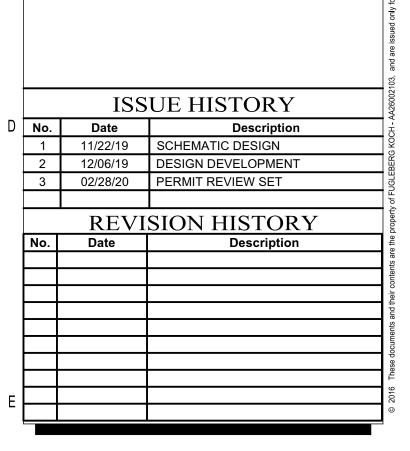

PERMIT REVIEW STAMP





THIS ITEM HAS BEEN ELECTRONICALLY SIGNED AND SEALED BY JEFFREY A. KIRKMAN, PE ON DATE INDICATED IN DIGITAL SIGNATURE USING A DIGITAL SIGNATURE.

PRINTED COPIES OF THIS DOCUMENT ARE NOT CONSIDERED SIGNED AND SEALED AND THE SIGNATURE MUST BE VERIFIED ON ANY ELECTRONIC COPIES.

THE ROBERT

FT. MYERS, FL

RISER DIAGRAMS -PLUMBING

P5.04

07777

